



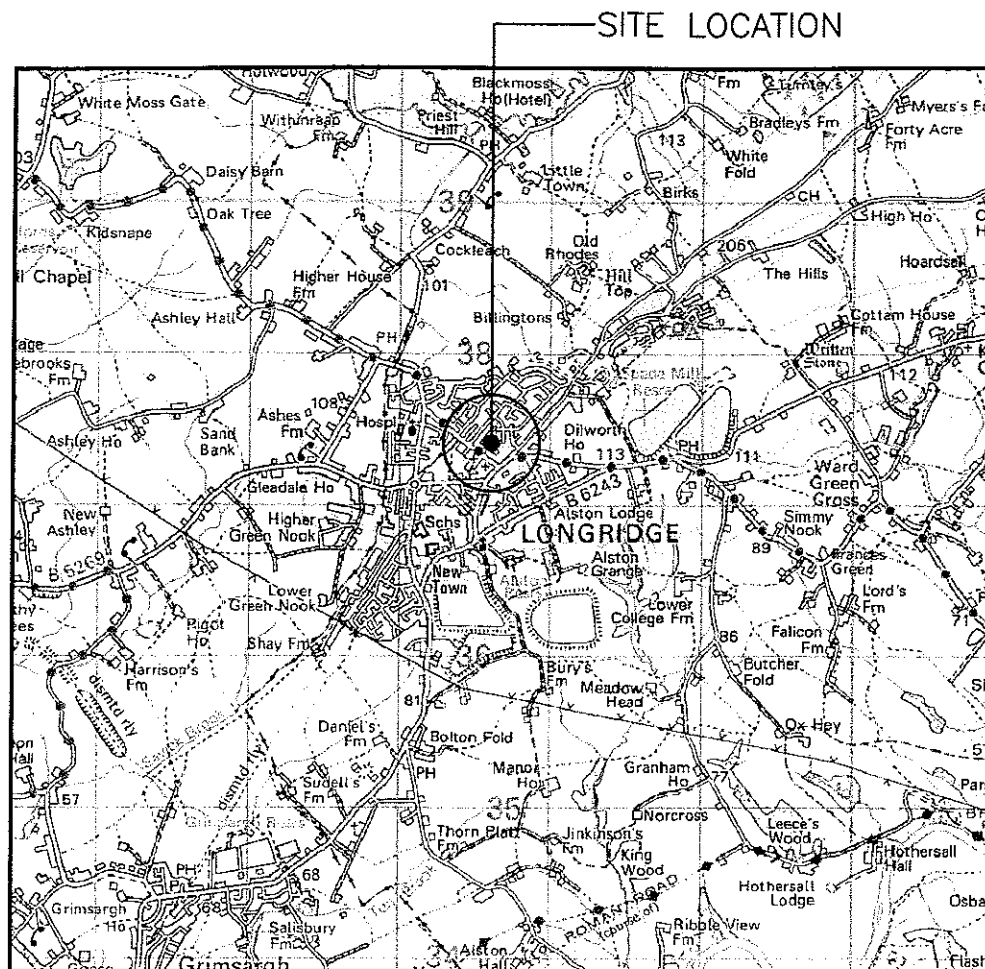


SITE LOCATION

SITE LOCATION
(Scale 1:50000)

Ordnance Survey map extract
based upon Landranger map series
with the permission of the controller of
Her Majesty's Stationery Office
Mono Consultants Limited licence no ES100017753
Crown copyright

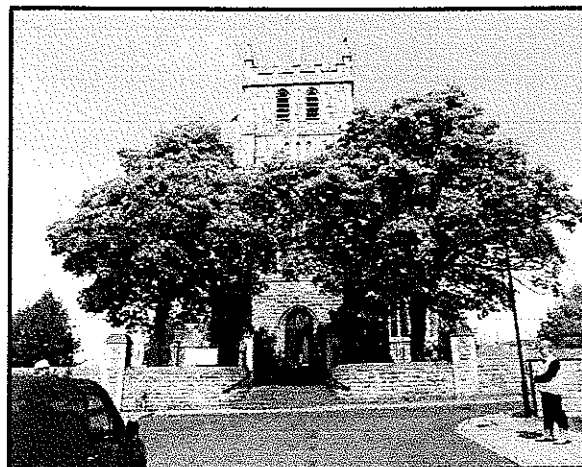


SITE PHOTOGRAPH

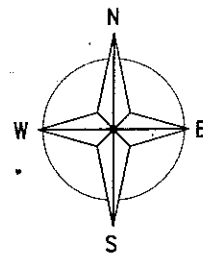

← - - - = Access Route
← - - - = Directions to Site

SITE LOCATION

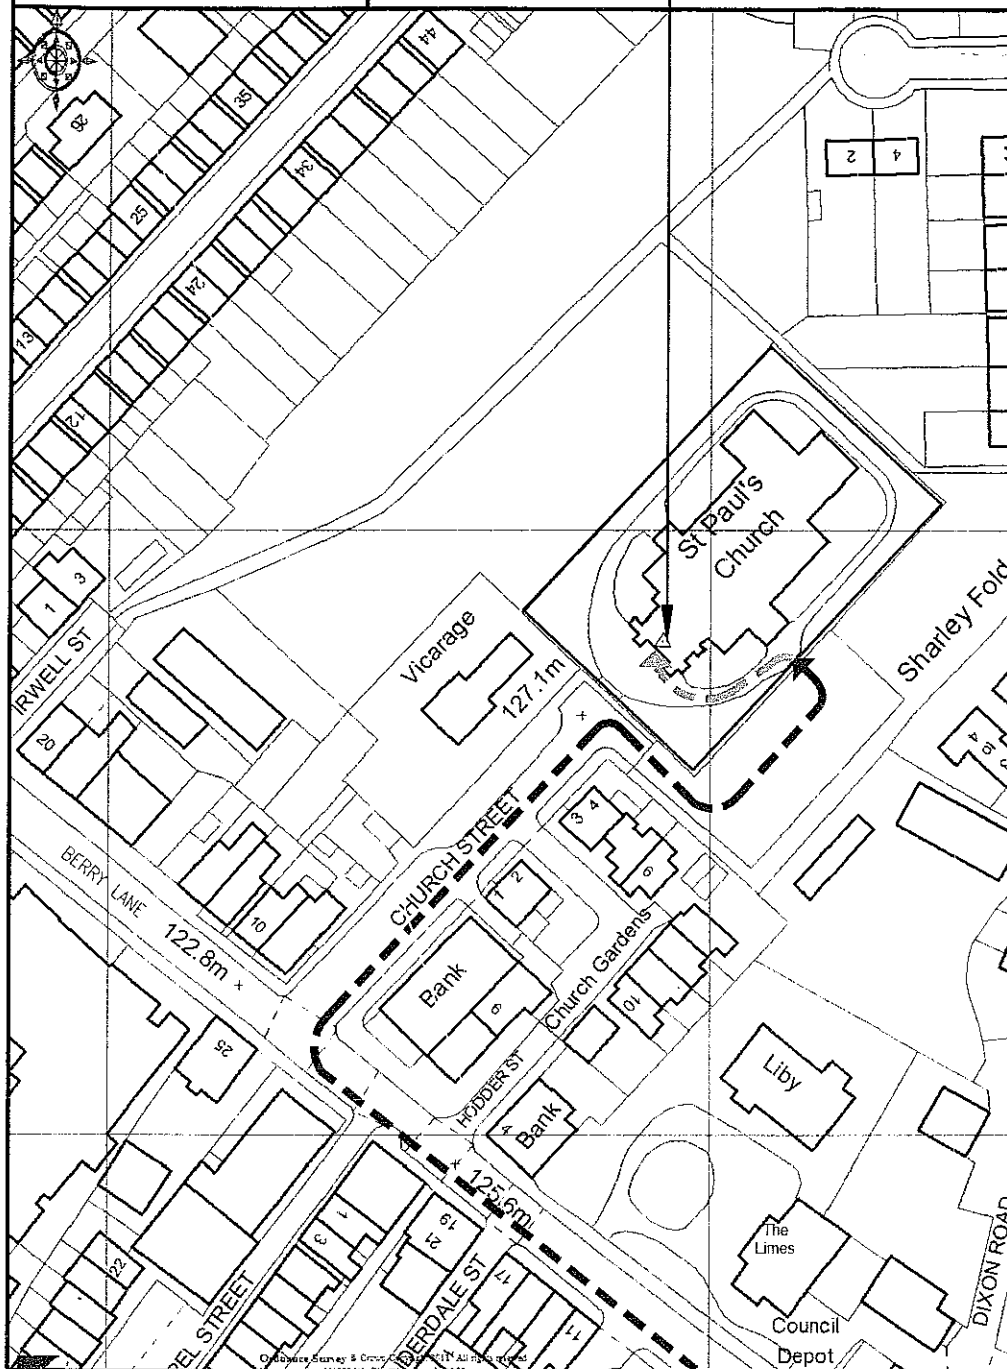

DETAILED SITE LOCATION
(Scale 1:1250)

Based upon Ordnance Survey map extract
with the permission of the Controller of
Her Majesty's Stationery Office
Crown copyright
Mono Consultants Limited licence no. ES100017753
Promap licence no. A152065A0001

Notes:
1 ALL DIMENSIONS ARE IN MM UNLESS NOTED OTHERWISE


N.G.R. E: 360592 N: 437382

Directions

Heading North on the M6, exit at junction 32 onto the M55 motorway for 0.5 miles and at junction 1 exit onto the A6. At the roundabout take the 3rd exit onto the A6 for 0.8 miles. Turn right onto B5269/Whittingham Lane for 2.9 miles then turn right onto B5269/Curneragh Lane for 2.8 miles. Turn Left onto Market Place and take the 1st left onto Berry Lane. Then take the 3rd right onto Church Street and the site is located at the top of the hill.

REV	MODIFICATION	BY	CH	DATE
A	Issued for Approval	SPD	PP	26.07.11

mono #
MONO CONSULTANTS LIMITED
Packwood House
Guild Street
Stratford-upon-Avon
CV37 6RP
t. 44 (0)1789 290099
f. 44 (0)1789 290088
www.monoconsultants.com

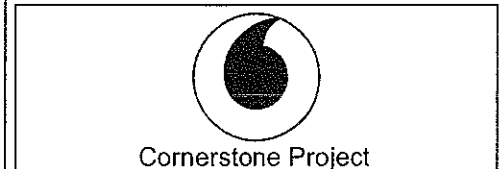

Cell Name	Opt
ST PAUL'S CHURCH 'OPTION A'	A

Cornerstone	Host	Sharer
(CS) 20076	(VF) 15122	(02) N/A


Site Address / Contact Details
ST PAUL'S CHURCH
BERRY LANE
LONGRIDGE
LANCASHIRE
PR3 3WA

Drawing Title: SITE LOCATION MAPS

Purpose of issue: PLANNING

Drawing Number: 100

Scale:		Drawn:		Date:		Issue:
As Shown		SPD		26.07.11		
Checked:	Date:	Approved:		Date:		3
PP	26.07.11	AB		26.07.11		

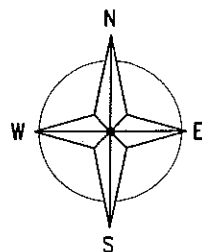

PROPOSED VODAFONE 1No. FACE
MOUNTED 900/2100 ANTENNA PAINTED
TO MATCH EXISTING STONEMWORK

PROPOSED VODAFONE 3No. POLE
MOUNTED 900/2100 ANTENNAS FIXED
TO INTERNAL STONEMWORK WALL
BEHIND GRP LOUVRES

PROPOSED VODAFONE INTERNAL
EQUIPMENT ROOM IN FLOOR
LEVEL BELOW ROOF

PROPOSED SUB METER TO BE
INSTALLED WITHIN LL ELECTRICAL
CUPBOARD ON GROUND FLOOR

ELEVATION

PROPOSED SUB MAIN CABLE TO FOLLOW
INTERNAL ROUTE, RISING THROUGH EACH
FLOOR LEVEL AND FIXED TO UNDERSIDE
OF EQUIPMENT ROOM FLOOR, THROUGH
FLOOR TO PROPOSED DISTRIBUTION
BOARD WITHIN EQUIPMENT ROOM

PROPOSED SITE PLAN

(1:200)

The drawings comply with O2 & Vodafone Standard ICNIRP guidelines.
Designed in accordance with Cornerstone document: CORN/09/013


Notes:
1 ALL DIMENSIONS ARE IN MM UNLESS NOTED OTHERWISE

N.G.R. E: 360592 N: 437382

320111040P

REV	MODIFICATION	BY	CH	DATE
B	Sub Meter and Main shown	SPD	PP	09.11.11
A	Issued for Approval	SPD	PP	26.07.11

mono #
MONO CONSULTANTS LIMITED
Packwood House
Guild Street
Stratford-upon-Avon
CV37 6RP
t 44 (0)1789 290099
f. 44 (0)1789 290088
www.monoconsultants.com

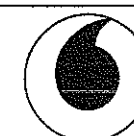

Cornerstone Project

Cell Name Opt

ST PAUL'S CHURCH 'OPTION A' A

Cell ID No

Cornerstone	Host	Sharer
(CS) 20076	(VF) 15122	(02) N/A

Site Address / Contact Details


ST PAUL'S CHURCH
BERRY LANE
LONGRIDGE
LANCASHIRE
PR3 3WA

Drawing Title: PROPOSED SITE PLAN

Purpose of issue: PLANNING

Drawing Number: 200

Scale:		Drawn:	Date:	Issue:
As Shown		SPD	26.07.11	
Checked:	Date:	Approved:	Date:	3
PP	26.07.11	AB	26.07.11	

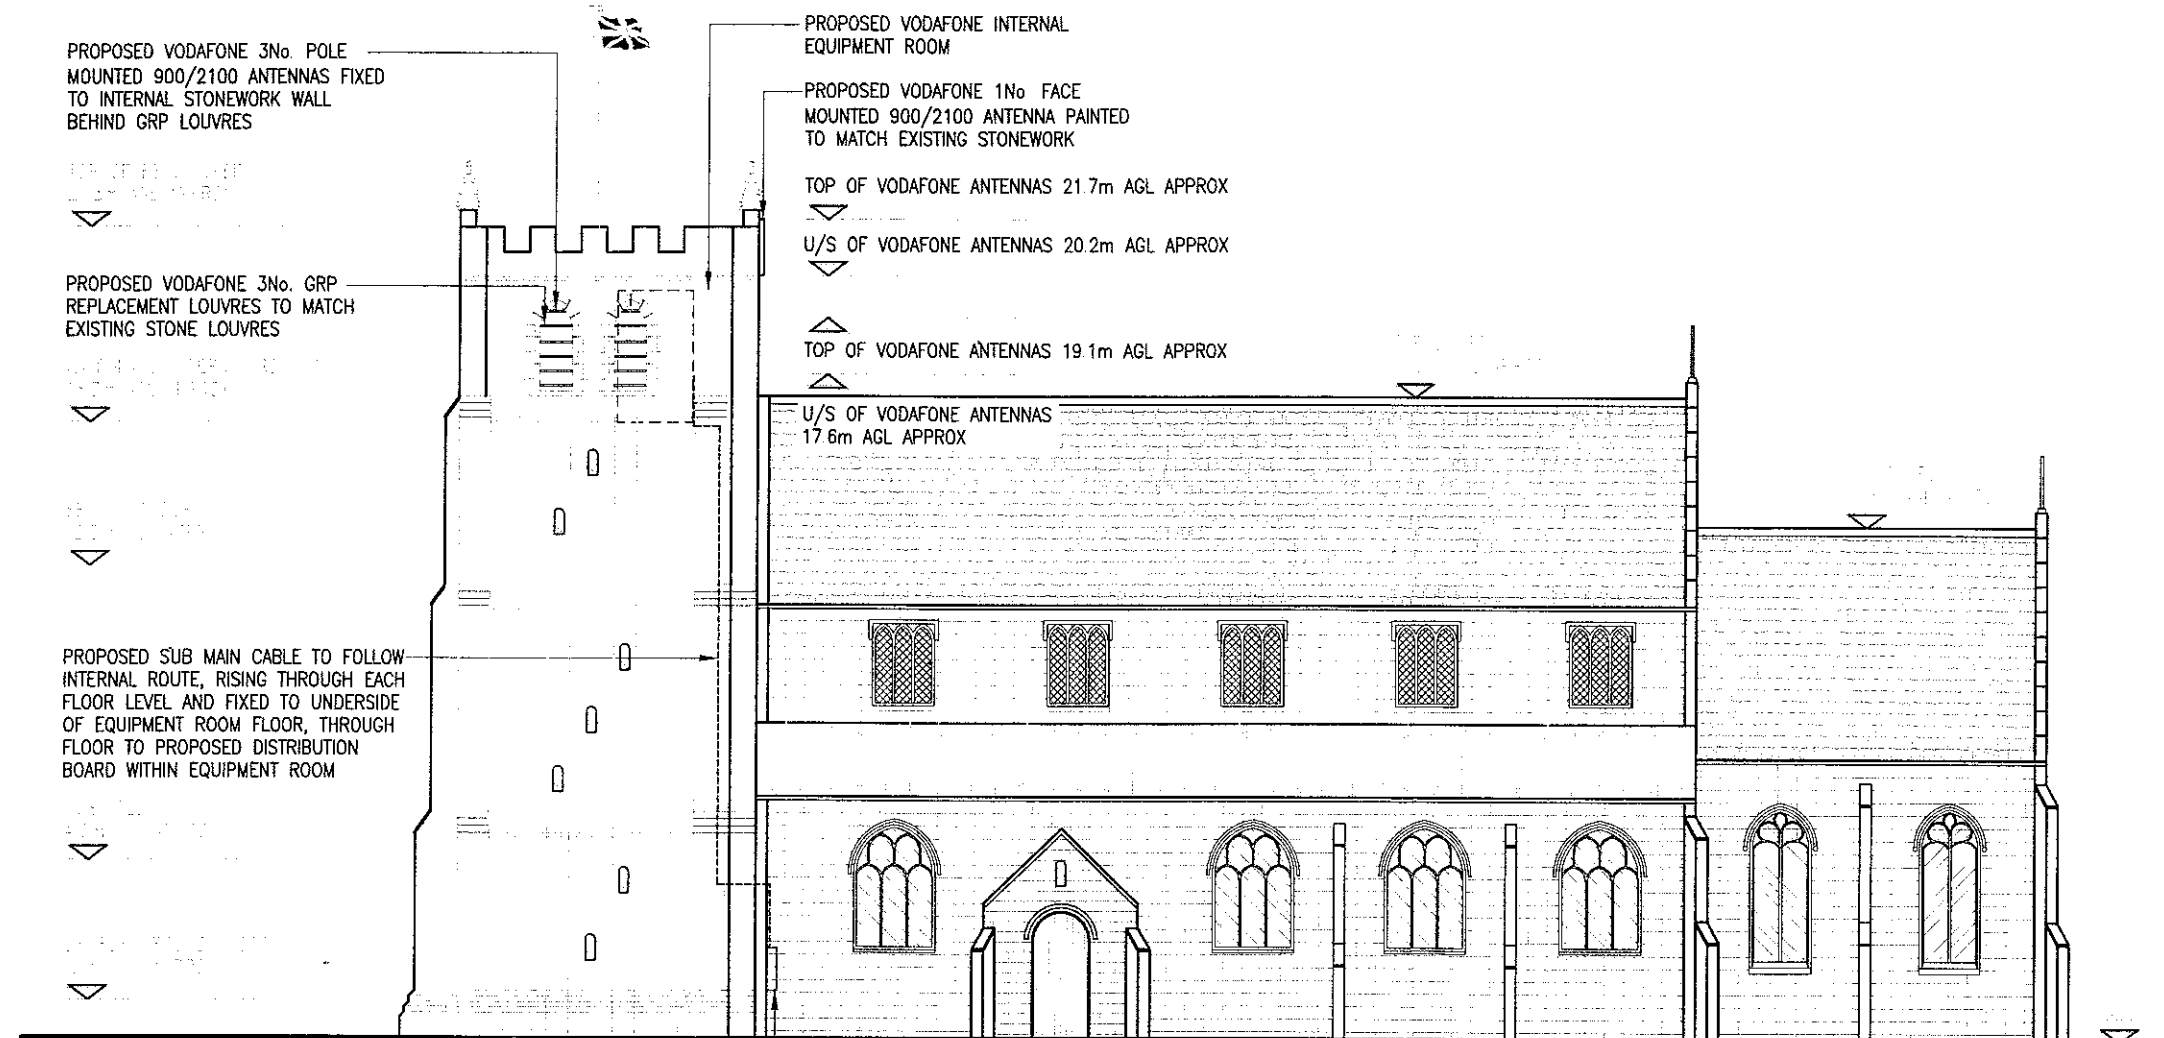

PROPOSED SOUTH EAST ELEVATION
(1:200)

The drawings comply with O2 & Vodafone Standard ICNIRP guidelines.
Designed in accordance with Cornerstone document: CORN/09/013


Notes:
1 ALL DIMENSIONS ARE IN MM UNLESS NOTED OTHERWISE

N.G.R. E: 360592 N: 437382

320111040P

REV	MODIFICATION	BY	CH	DATE
C	Sub main route amended	SPD	PP	24.11.11
B	Sub Meter and Main shown	SPD	PP	09.11.11
A	Issued for Approval	SPD	PP	26.07.11

mono #
MONO CONSULTANTS LIMITED
Packwood House
Guild Street
Stratford-upon-Avon
CV37 6RP
t 44 (0)1789 290099
f. 44 (0)1789 290088
www.monoconsultants.com

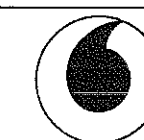

Cornerstone Project

Cell Name Opt

ST PAUL'S CHURCH 'OPTION A' A

Cell ID No

Cornerstone	Host	Sharer
(CS) 20076	(VF) 15122	(02) N/A

Site Address / Contact Details



ST PAUL'S CHURCH
BERRY LANE
LONGRIDGE
LANCASHIRE
PR3 3WA

Drawing Title: PROPOSED SITE ELEVATION


Purpose of issue: PLANNING

Drawing Number: 300

Scale:		As Shown		Drawn:	SPD	Date:	26.07.11	Issue:
Checked:	PP	Date:	26.07.11	Approved:	AB	Date:	26.07.11	3

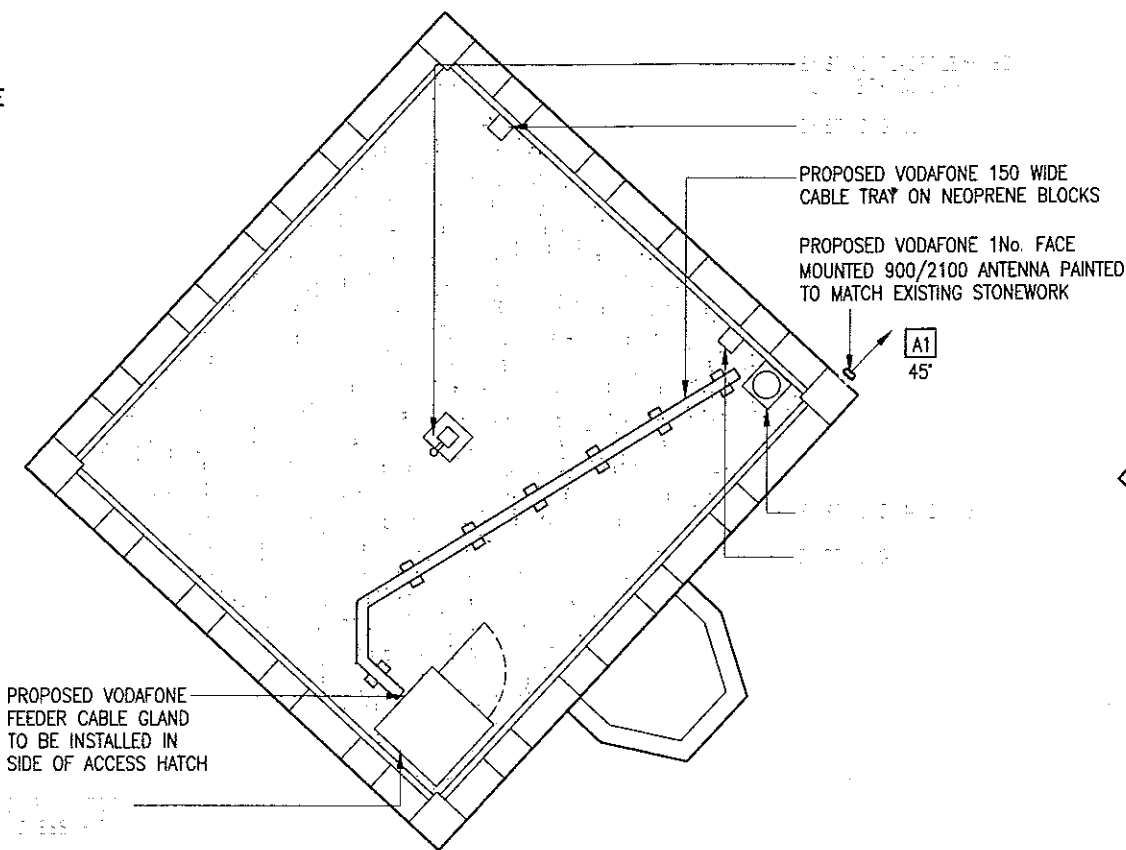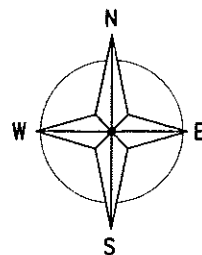

PROPOSED VODAFONE ANTENNA PLAN (ROOF LEVEL)
(1:100)

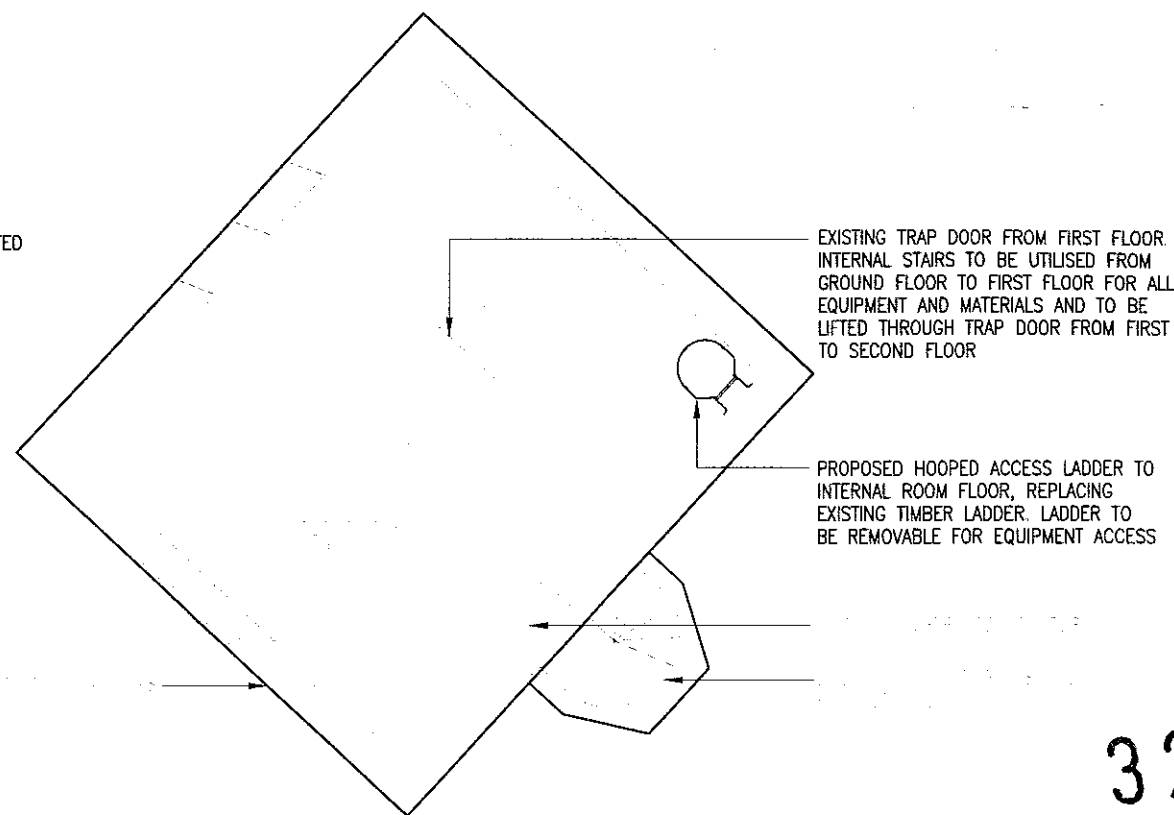

PROPOSED 2nd FLOOR LAYOUT
(1:100)

NOTE:
PROPOSED VODAFONE POWER SUPPLY TO BE FED FROM EXISTING CHURCH DISTRIBUTION BOARD, SUBJECT TO MONO ELECTRICAL SURVEY

PROPOSED BT EQUIPMENT ON NEW 600x600 BACKBOARD FOR 2No. MEAS BRACKETS


PROPOSED 2No VODAFONE WALL MOUNTED A/C UNITS

PROPOSED 2No ROXTEC GLANDS WITHIN TIMBER STUD WALL

PROPOSED VODAFONE 450 WIDE CABLE TRAY FIXED TO WALL AT HIGH LEVEL

PROPOSED VODAFONE PSU

PROPOSED VODAFONE 2No. RBS 2206 s

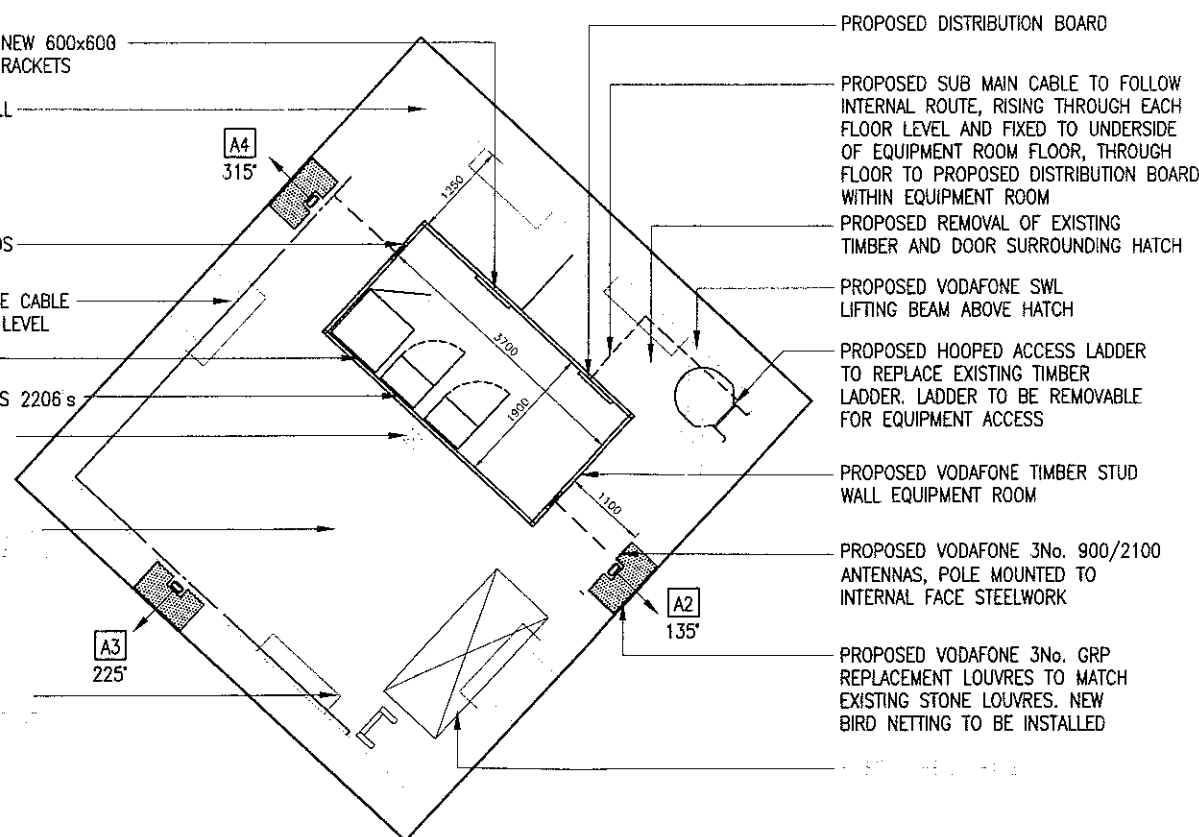

PROPOSED INTERNAL ROOM/ANTENNA LAYOUT (3rd FLOOR)
(1:100)

The drawings comply with O2 & Vodafone Standard ICNIRP guidelines.
Designed in accordance with Cornerstone document: CORN/09/013


Notes:
1 ALL DIMENSIONS ARE IN MM UNLESS NOTED OTHERWISE

N.G.R. E: 360592 N: 437382

320111040P

REV	MODIFICATION	BY	CH	DATE
C	Sub main route amended	SPD	PP	24.11.11
B	Sub main route shown	SPD	PP	09.11.11
A	Issued for Approval	SPD	PP	26.07.11

MONO CONSULTANTS LIMITED
Packwood House
Guild Street
Stratford-upon-Avon
CV37 6RP
t 44 (0)1789 290099
f 44 (0)1789 290088
www.monoconsultants.com

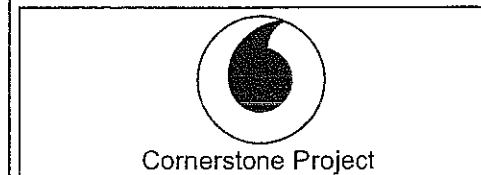

Cell Name			Op
ST PAUL'S CHURCH 'OPTION A'			/
Cell ID No			
Cornerstone		Host	Sharer
(CS) 20076	(VF) 15122	(02) N/A	
Site Address / Contact Details			

Site Address / Contact Details
ST PAUL'S CHURCH
BERRY LANE
LONGRIDGE
LANCASHIRE
PR3 3WA

Drawing Title:	ANTENNA & INTERNAL ROOM LAYOUT			
Purpose of issue:	PLANNING			
Drawing Number:	400			
Scale:	As Shown	Drawn:	SPD	Date: 26.07.11
Checked:	PP	Date:	26.07.11	Approved: AB
		Date:	26.07.11	Issue: 3