


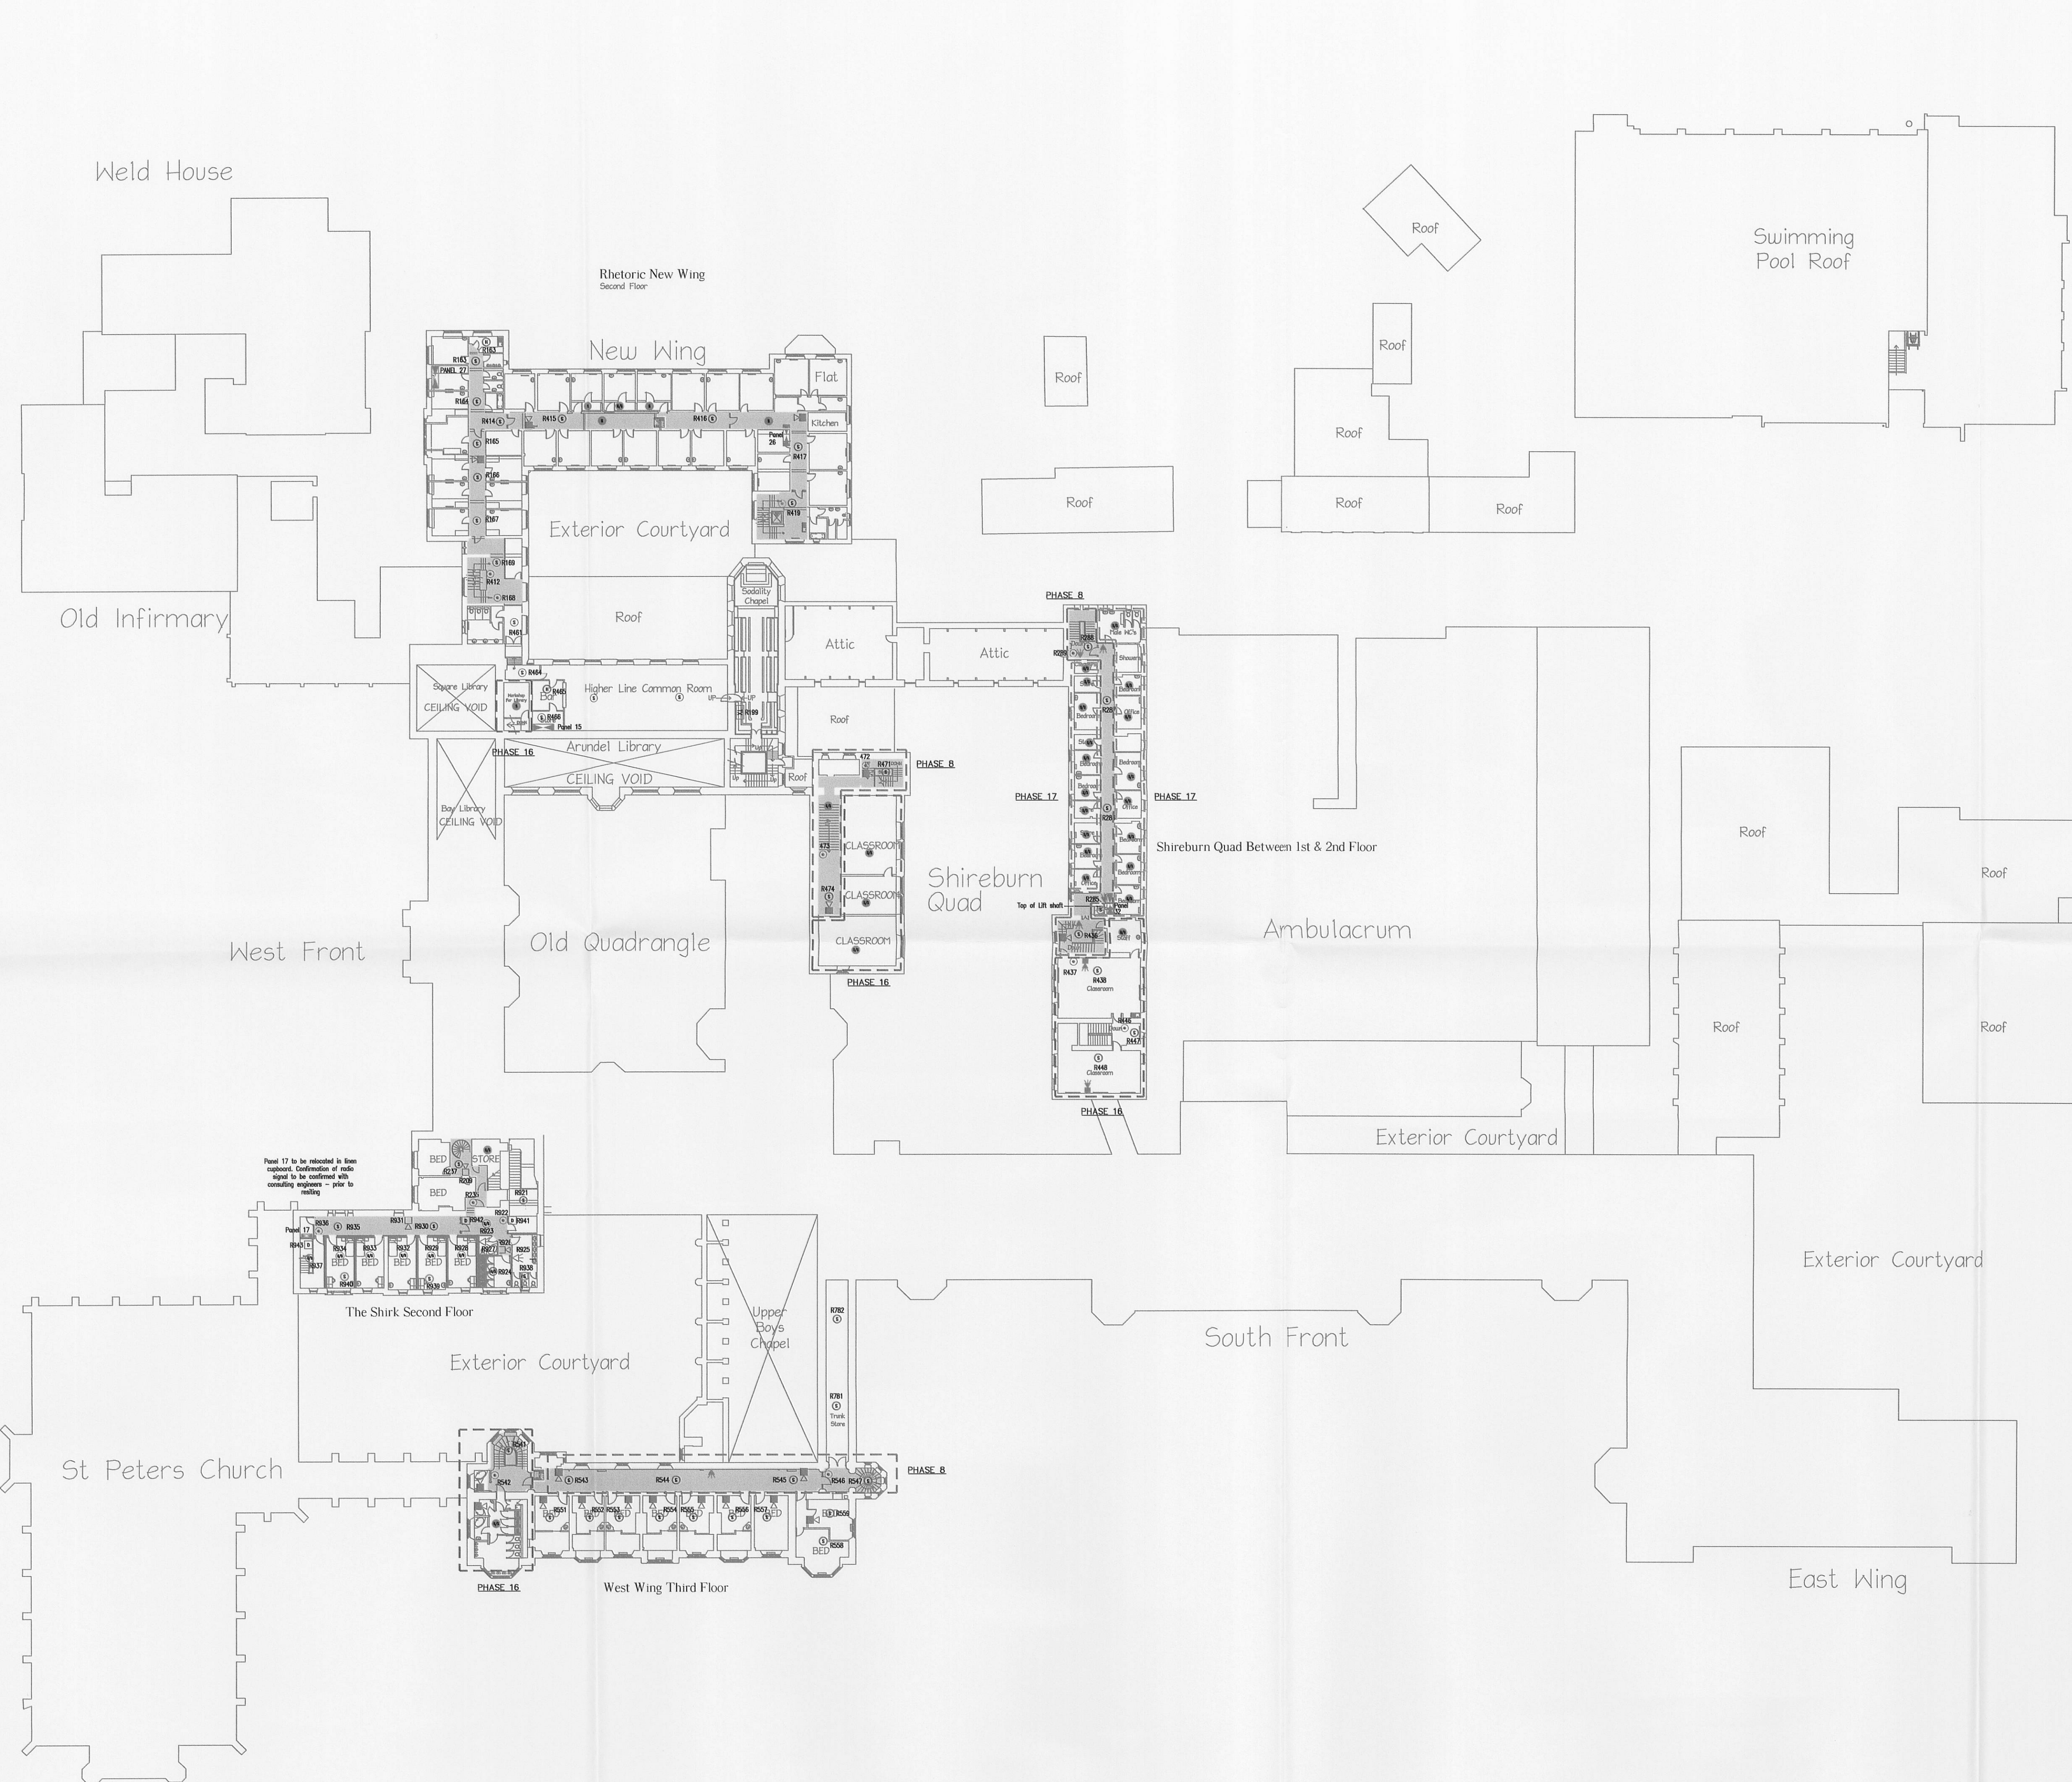

LEGEND

R (●) Denotes call point (Radio)

■ Denotes sounder (Hardwired)

R (■) Denotes sounder (Radio)

R (□) Denotes sounder beacon (Radio)

R (◁) Denotes beacon (Radio)

R (S) Denotes smoke detector (Radio)

R (S) Denotes smoke sounder base detector (Radio)

R (S) Denotes smoke detector in Ceiling Void (Radio)

R (H) Denotes heat detector

R (H) Denotes heat detector

R (H) Denotes heat detector sounder base

Panel 2 – Adjacent to boiler house / maintenance block
Denotes alarm indicator panels with visual display.
Panel 6 – Main communication at main reception (south fronts)

Panel 1, 2, 4 & 5
Denotes Sub-Main Alarm Indicator Panel
Provided with local 230V supply:

Panel 7-36
Denotes Radio Repeater Panel
Non-Indicator

SCB
Denotes Sounder Circuit Booster
Supplied by local 230V single phase supply:

H
Fire hydrant

H
Hose reel location

D
Fire alarm door actuator

VP
Fire alarm Vibrating pillow

M
Door Detente hold back magnet

R
Refuge alerter panel

DK
Electric door keep

I
Fire alarm interface unit

●
New Fire Alarm devices
as per risk assessment

STONYHURST

COLLEGE

UPGRADED TO L1/L2

D 15 NOV 2011 ADDITIONAL RISKS INCORPORATED AFTER CONSULTATION WITH LANCASHIRE FIRE & RESCUE SERVICE FIRE SAFETY OFFICER

C OCT 2011 ADDITIONAL DETECTION ADDED "SHIRK" BEDROOM AND THIRD FLOOR FLAT NEW WING.

B JULY 2011 ADDITIONAL FIRE ALARM DETECTION & EMERGENCY LIGHTING ADDED IN ACCORDANCE WITH RISK ASSESSMENTS

A AUG 2010 ROOF VOID DETECTION SHOWN IN GREEN

– APR 2010 AS FITTED

Rev	Date	Amendment
Draw: LB	Date: FEB97	Scale
Chkd: BH	Date: FEB97	NTS@A0

Project Title
STONYHURST COLLEGE CLITHEROE

Drawing Title
**INTERMEDIATE FLOOR PLANS
FIRE ALARM INSTALLATIONS
RISK ASSESSMENT SURVEY**

EDN

ENVIRONMENTAL DESIGN LTD
M&E BUILDING SERVICES CONSULTING ENGINEERS

Make Office Park, 10 Edin Avenue, Baultham Village, Chorley, PR7 7JA
Tel : 01773 337760 Fax : 01773 606069
email : mds@edn.co.uk

Drg. No.	Rev.
010.025.FA10	D

Intermediate Floor Plans