

LUMINAIRE SCHEDULE

Symbol	Qty	Catalog Number	Description	Lamp	Lumens	LLF
	3	ASM.150CDMTF3.FWC	AERIS MEDIUM FORWARD THROW CUTOFF @ 8 MTRS	150W CLEAR CDM-T 3000K METAL HALIDE (G12)	14000	0.83
	3	ASM.150CDMTF3.NR	AERIS MEDIUM LONG AND NARROW @ 8 MTRS	150W CLEAR CDM-T 3000K METAL HALIDE (G12)	14000	1.00
	6	ASM.150CDMTF3.AY	AERIS MEDIUM ASYMMETRICAL @ 8 MTRS	150W CLEAR CDM-T 3000K METAL HALIDE (G12)	14000	1.00

SAMLESBURY SITE - LOCATION PLAN

- SOUTH RIBBLE / RIBBLE VALLEY AUTHORITY BOUNDARY
- BAE SYSTEMS PROPERTY BOUNDARY
- APPLICATION BOUNDARY

Iss.	Date	Modification	Init.
E	02-08-12	PROJECT AREA AMENDED	DR
D	24-07-12	AREAS OF PROJECT ADDED	DR
C	24-07-12	KEY AMENDED	DR
B	10-07-12	REMOVED COLUMN FROM 210	DR
A	10-07-12	DRAWING ISSUED	DR


THIS IS A CONTROLLED DOCUMENT & HAS BEEN ISSUED TO:
NAME:
COMPANY:
NO PART OF THIS DRAWING MAY BE COPIED OR REPRODUCED OR ANY INFORMATION CONTAINED ON THIS DRAWING GIVEN TO A THIRD PARTY WITHOUT THE PRIOR WRITTEN PERMISSION OF:
**INVESTMENT & INFRASTRUCTURE SERVICES
BAE SYSTEMS LTD.**
THIS DRAWING CONTAINS INFORMATION HELD ON THE INVESTMENT & INFRASTRUCTURE SERVICES CAD SYSTEM AT THE DATE OF ISSUE ONLY
SIGNED: DATE:

320120800P


Investment & Infrastructure Services
BAE SYSTEMS plc
SAMLESBURY AERODROME
BALDERSTONE
BLACKBURN
LANCASHIRE
BB2 7LF
Tel: 01254 7 68903
- Samlesbury Site - © BAE SYSTEMS LIMITED. All rights reserved.

BAE SYSTEMS

Project Description 09S6353 - GOODS RECEIVING EXTERNAL LAYOUT	PRINTED: 02/08/2012 Building No: 3A Created: 10/07/12 Scale: 1:2500 @ A1 Printed at: 1:N.T.S. Created by: D RUSHTON
Title EXTERNAL LIGHTING PLAN FOR 210 BUILDING AND AEB	
Project No. 09S6353 / 029	Issue E

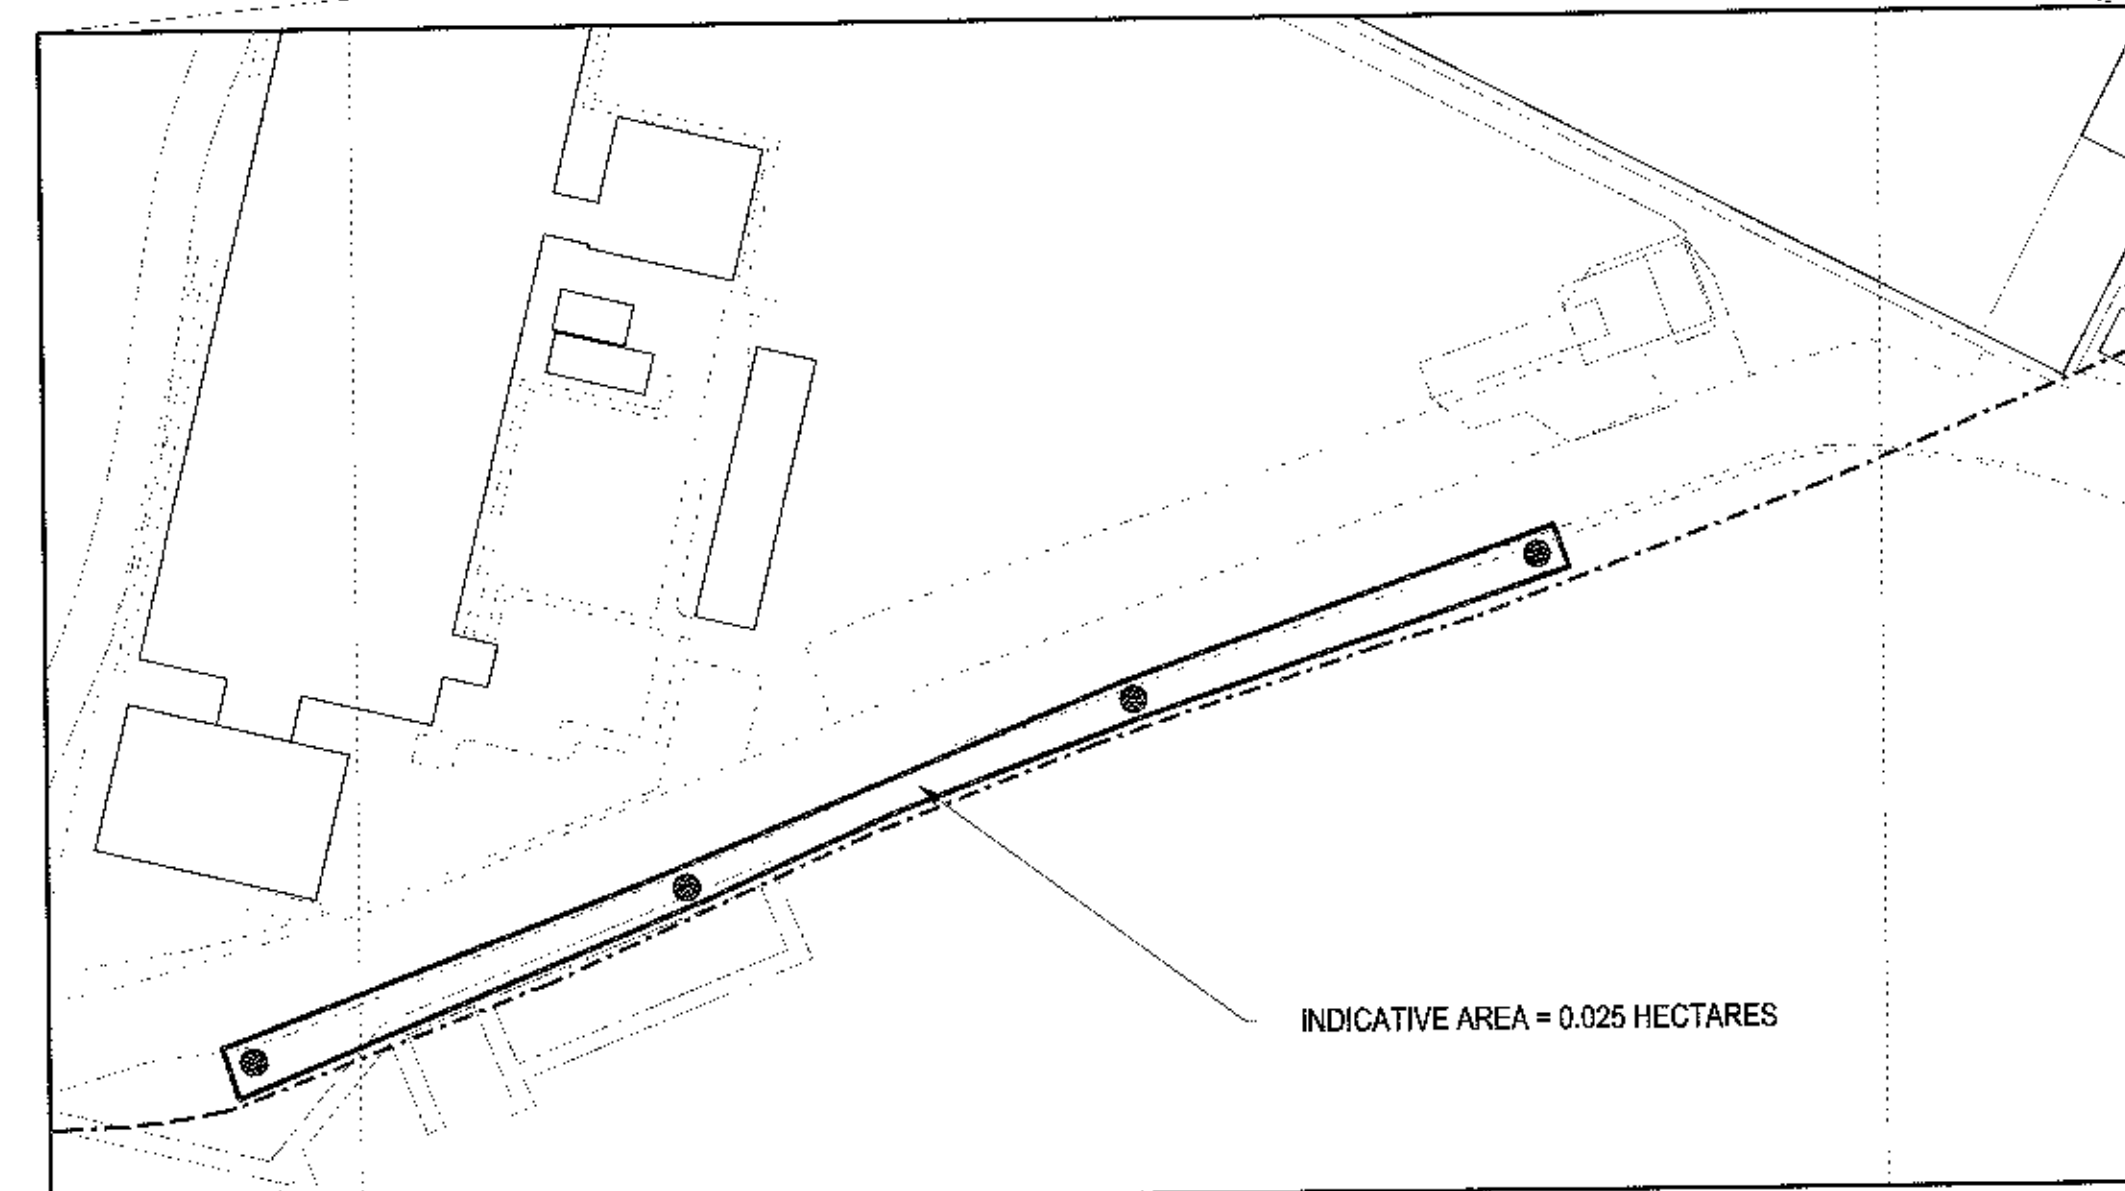

ENLARGED VIEW OF PROJECT AREA
SCALE = 500@A1

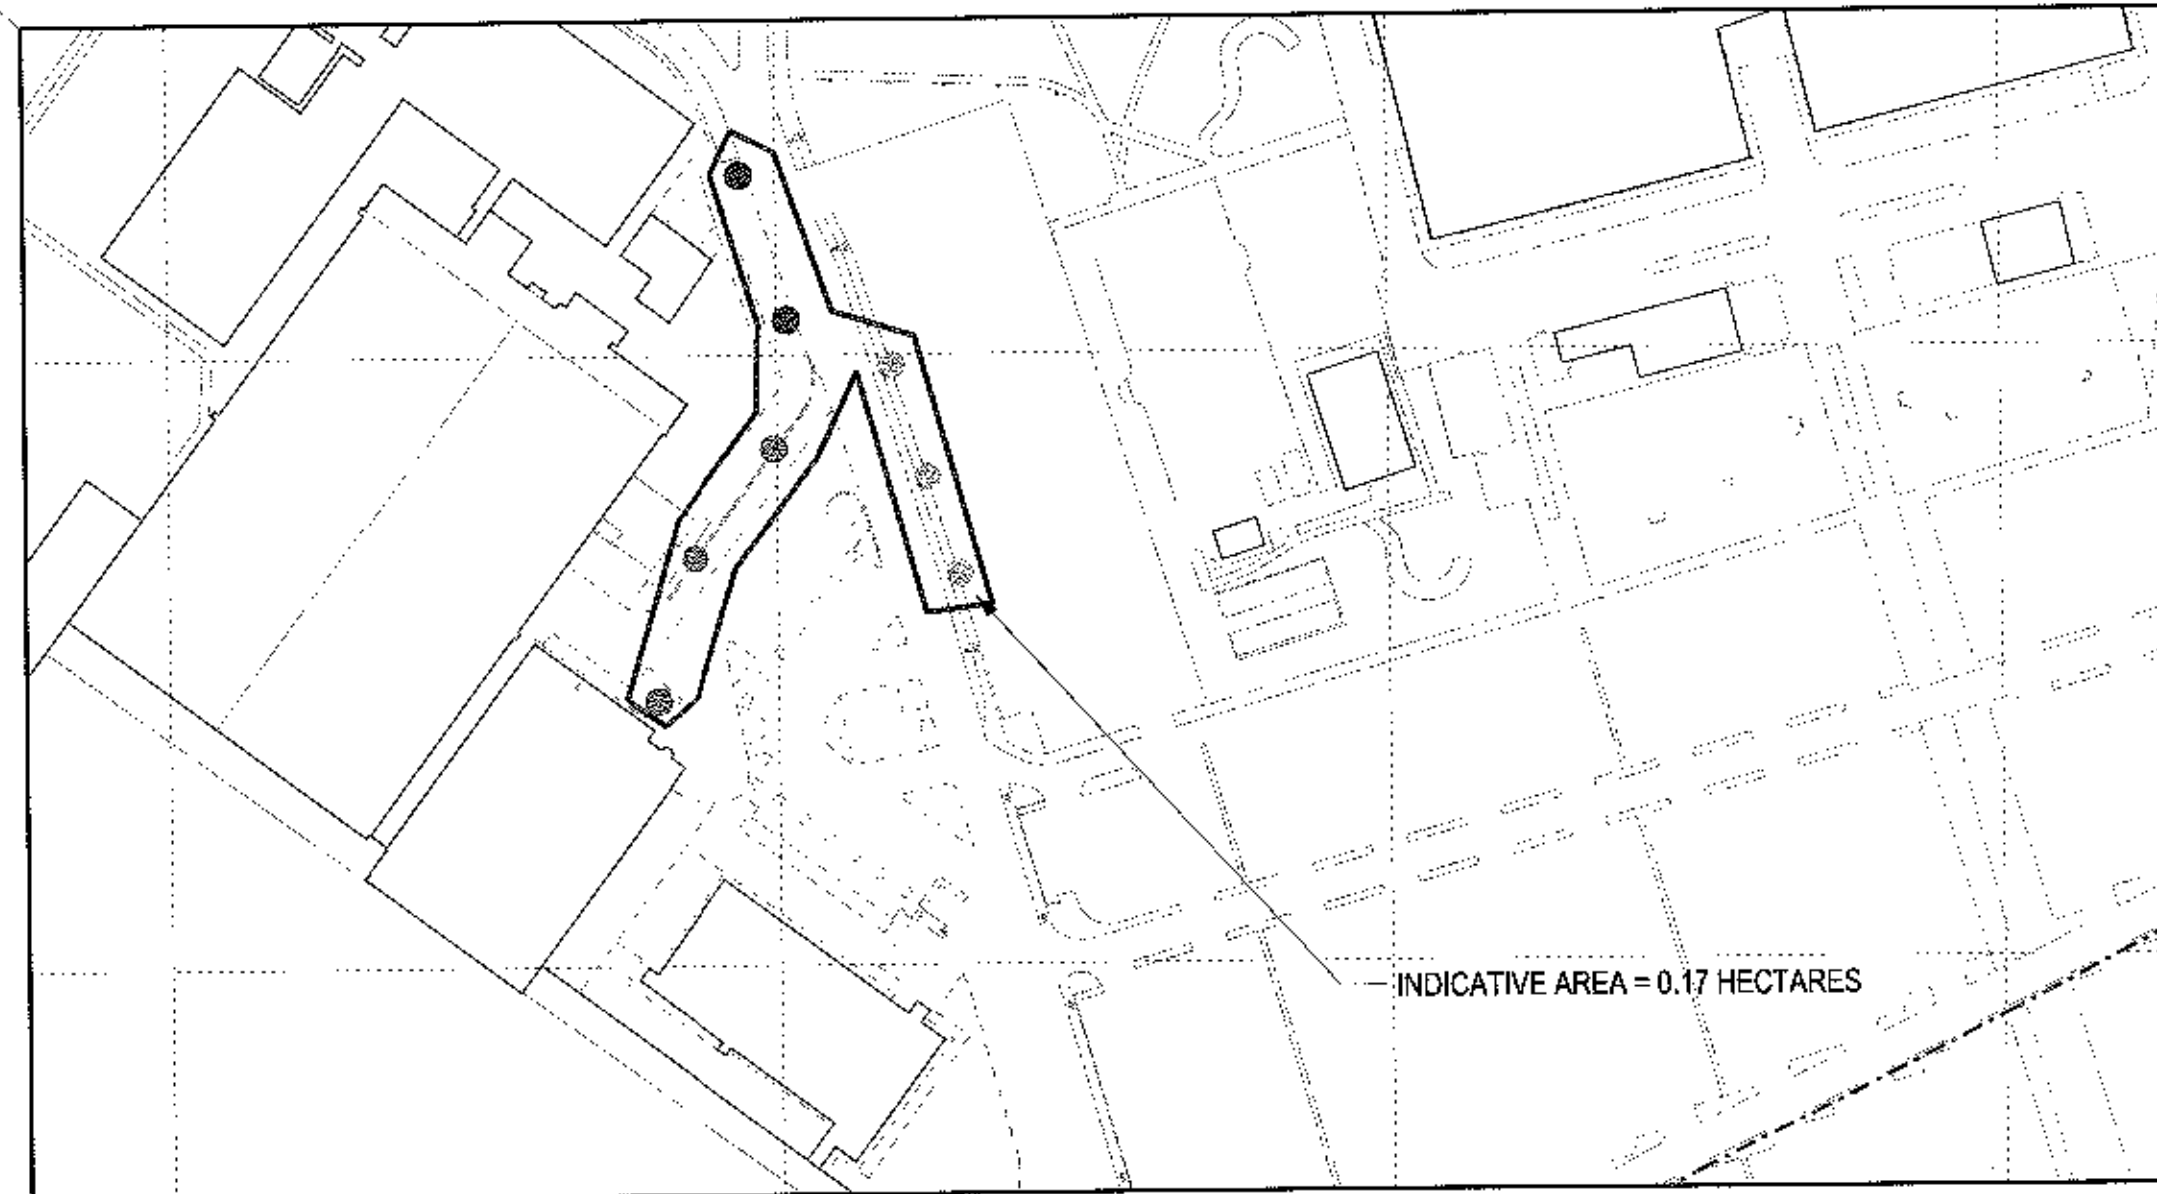

ENLARGED VIEW OF PROJECT AREA
SCALE = 1250@A1