
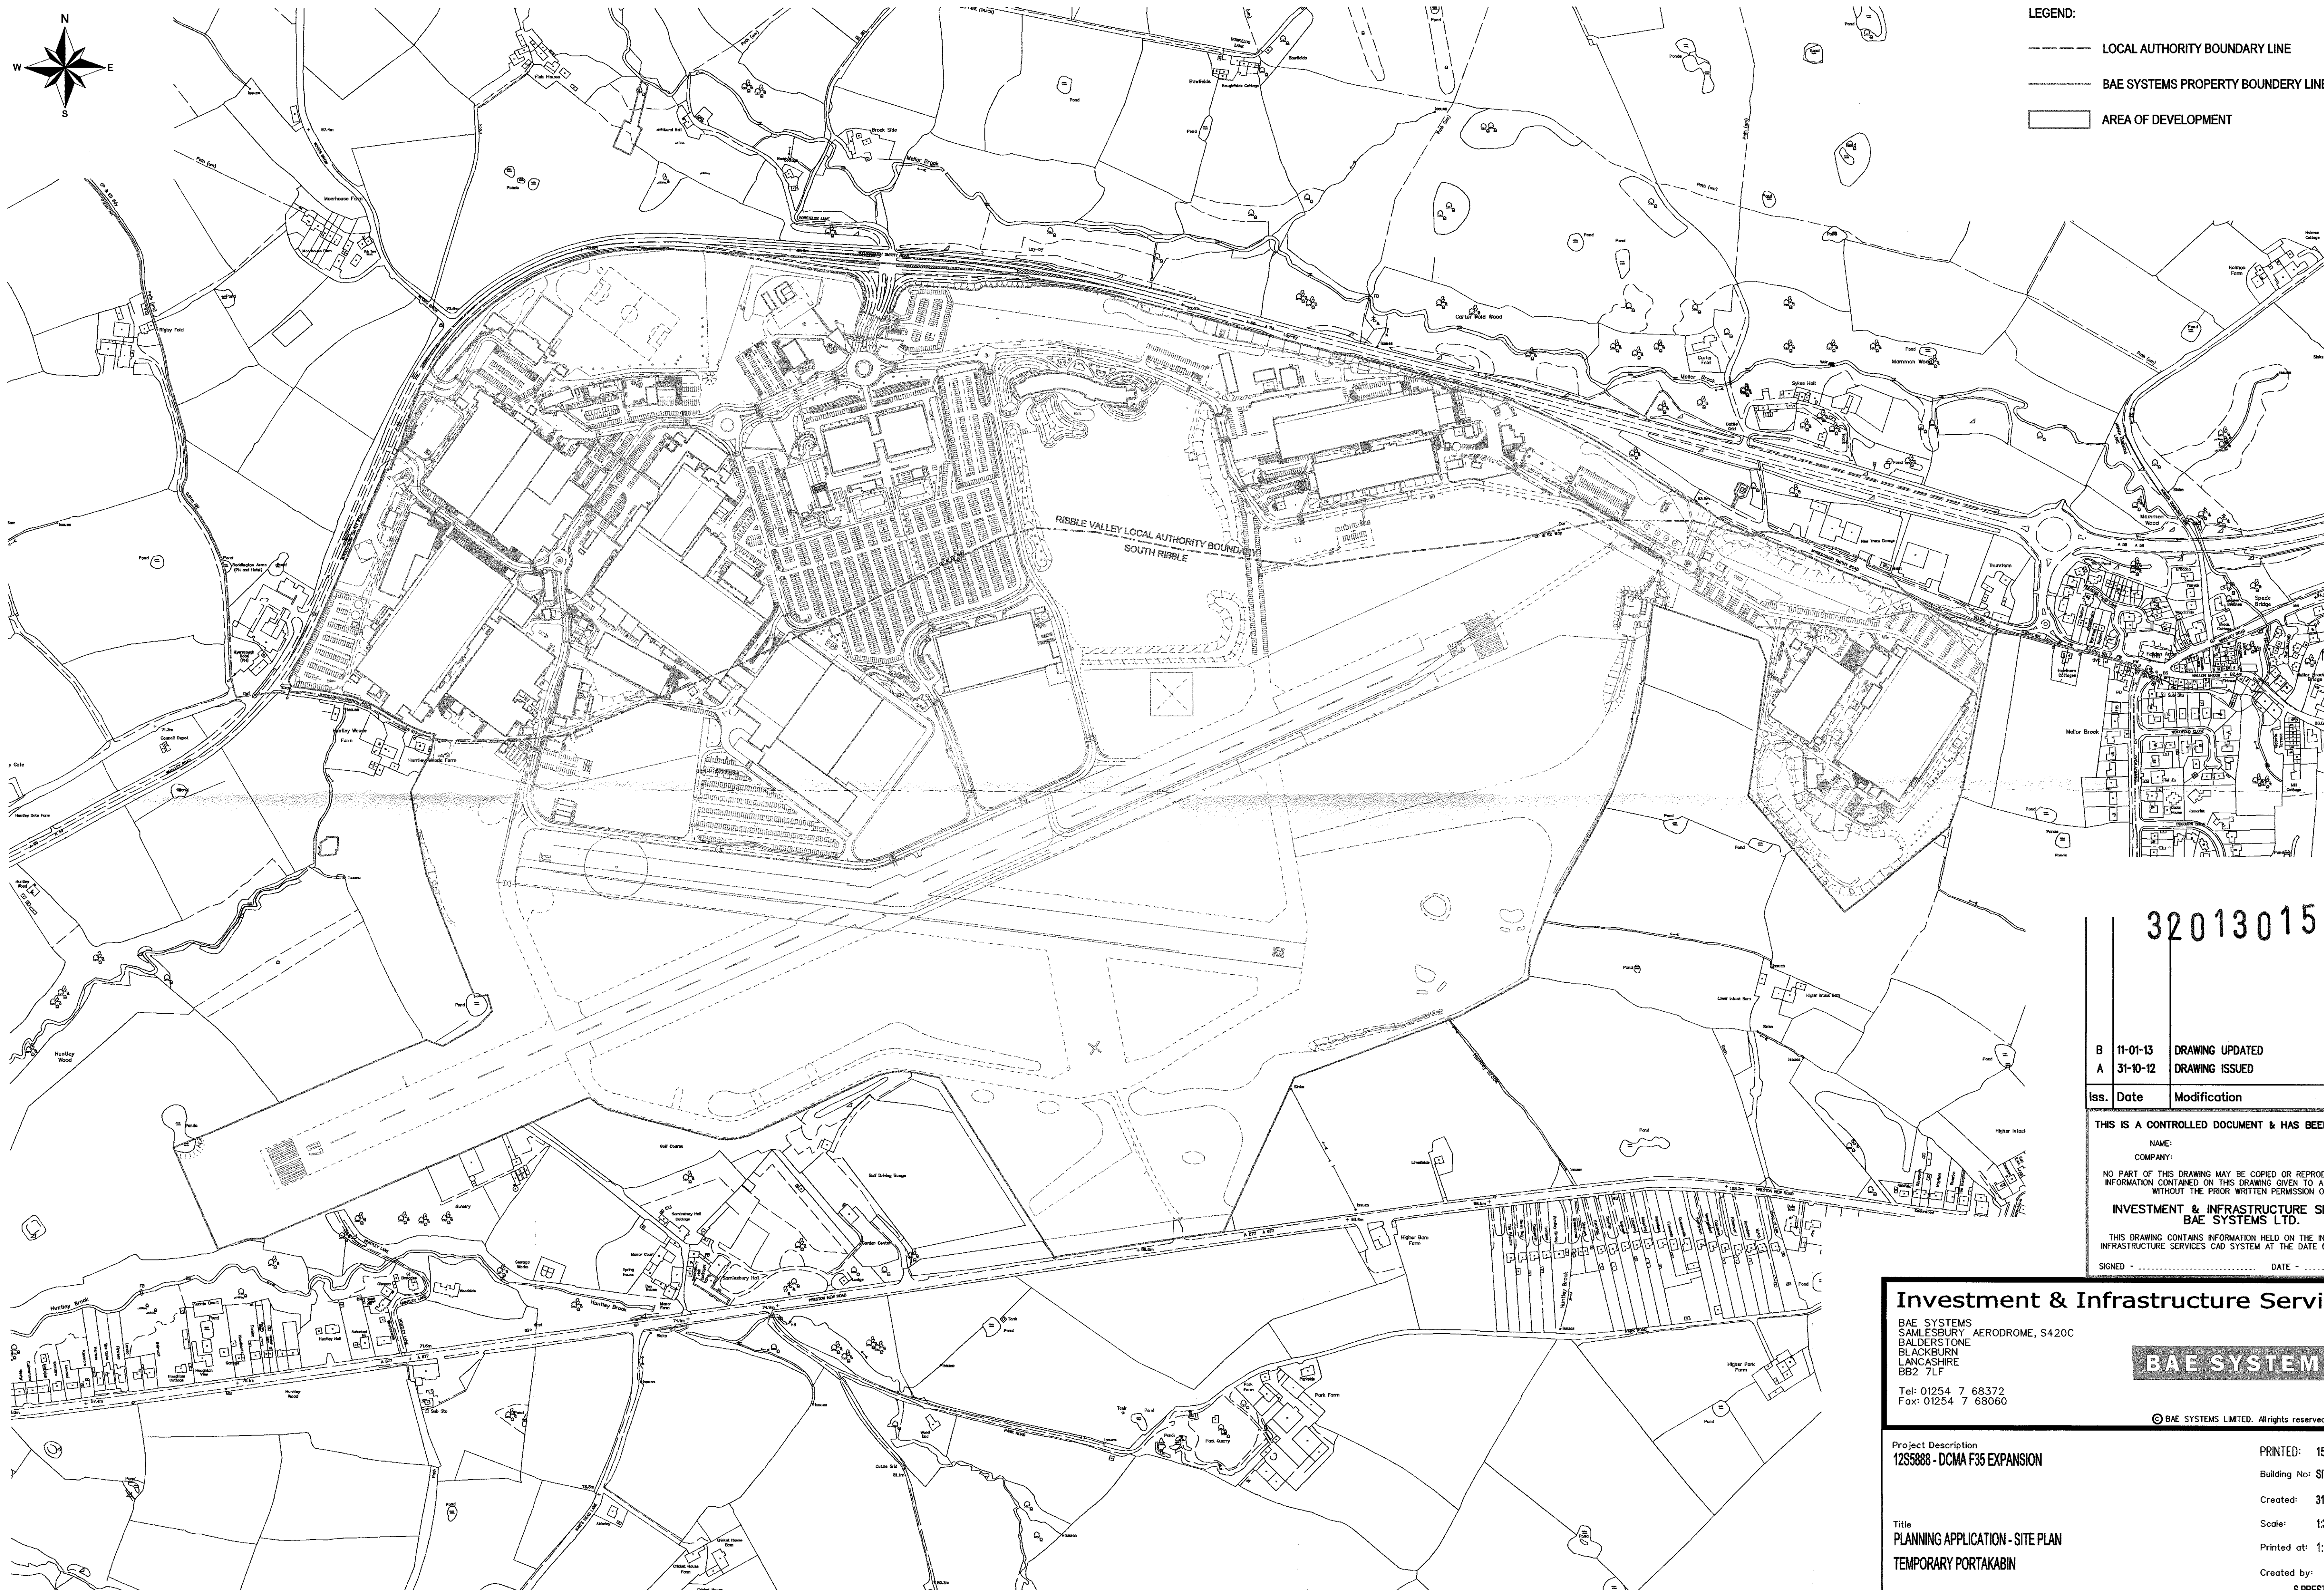


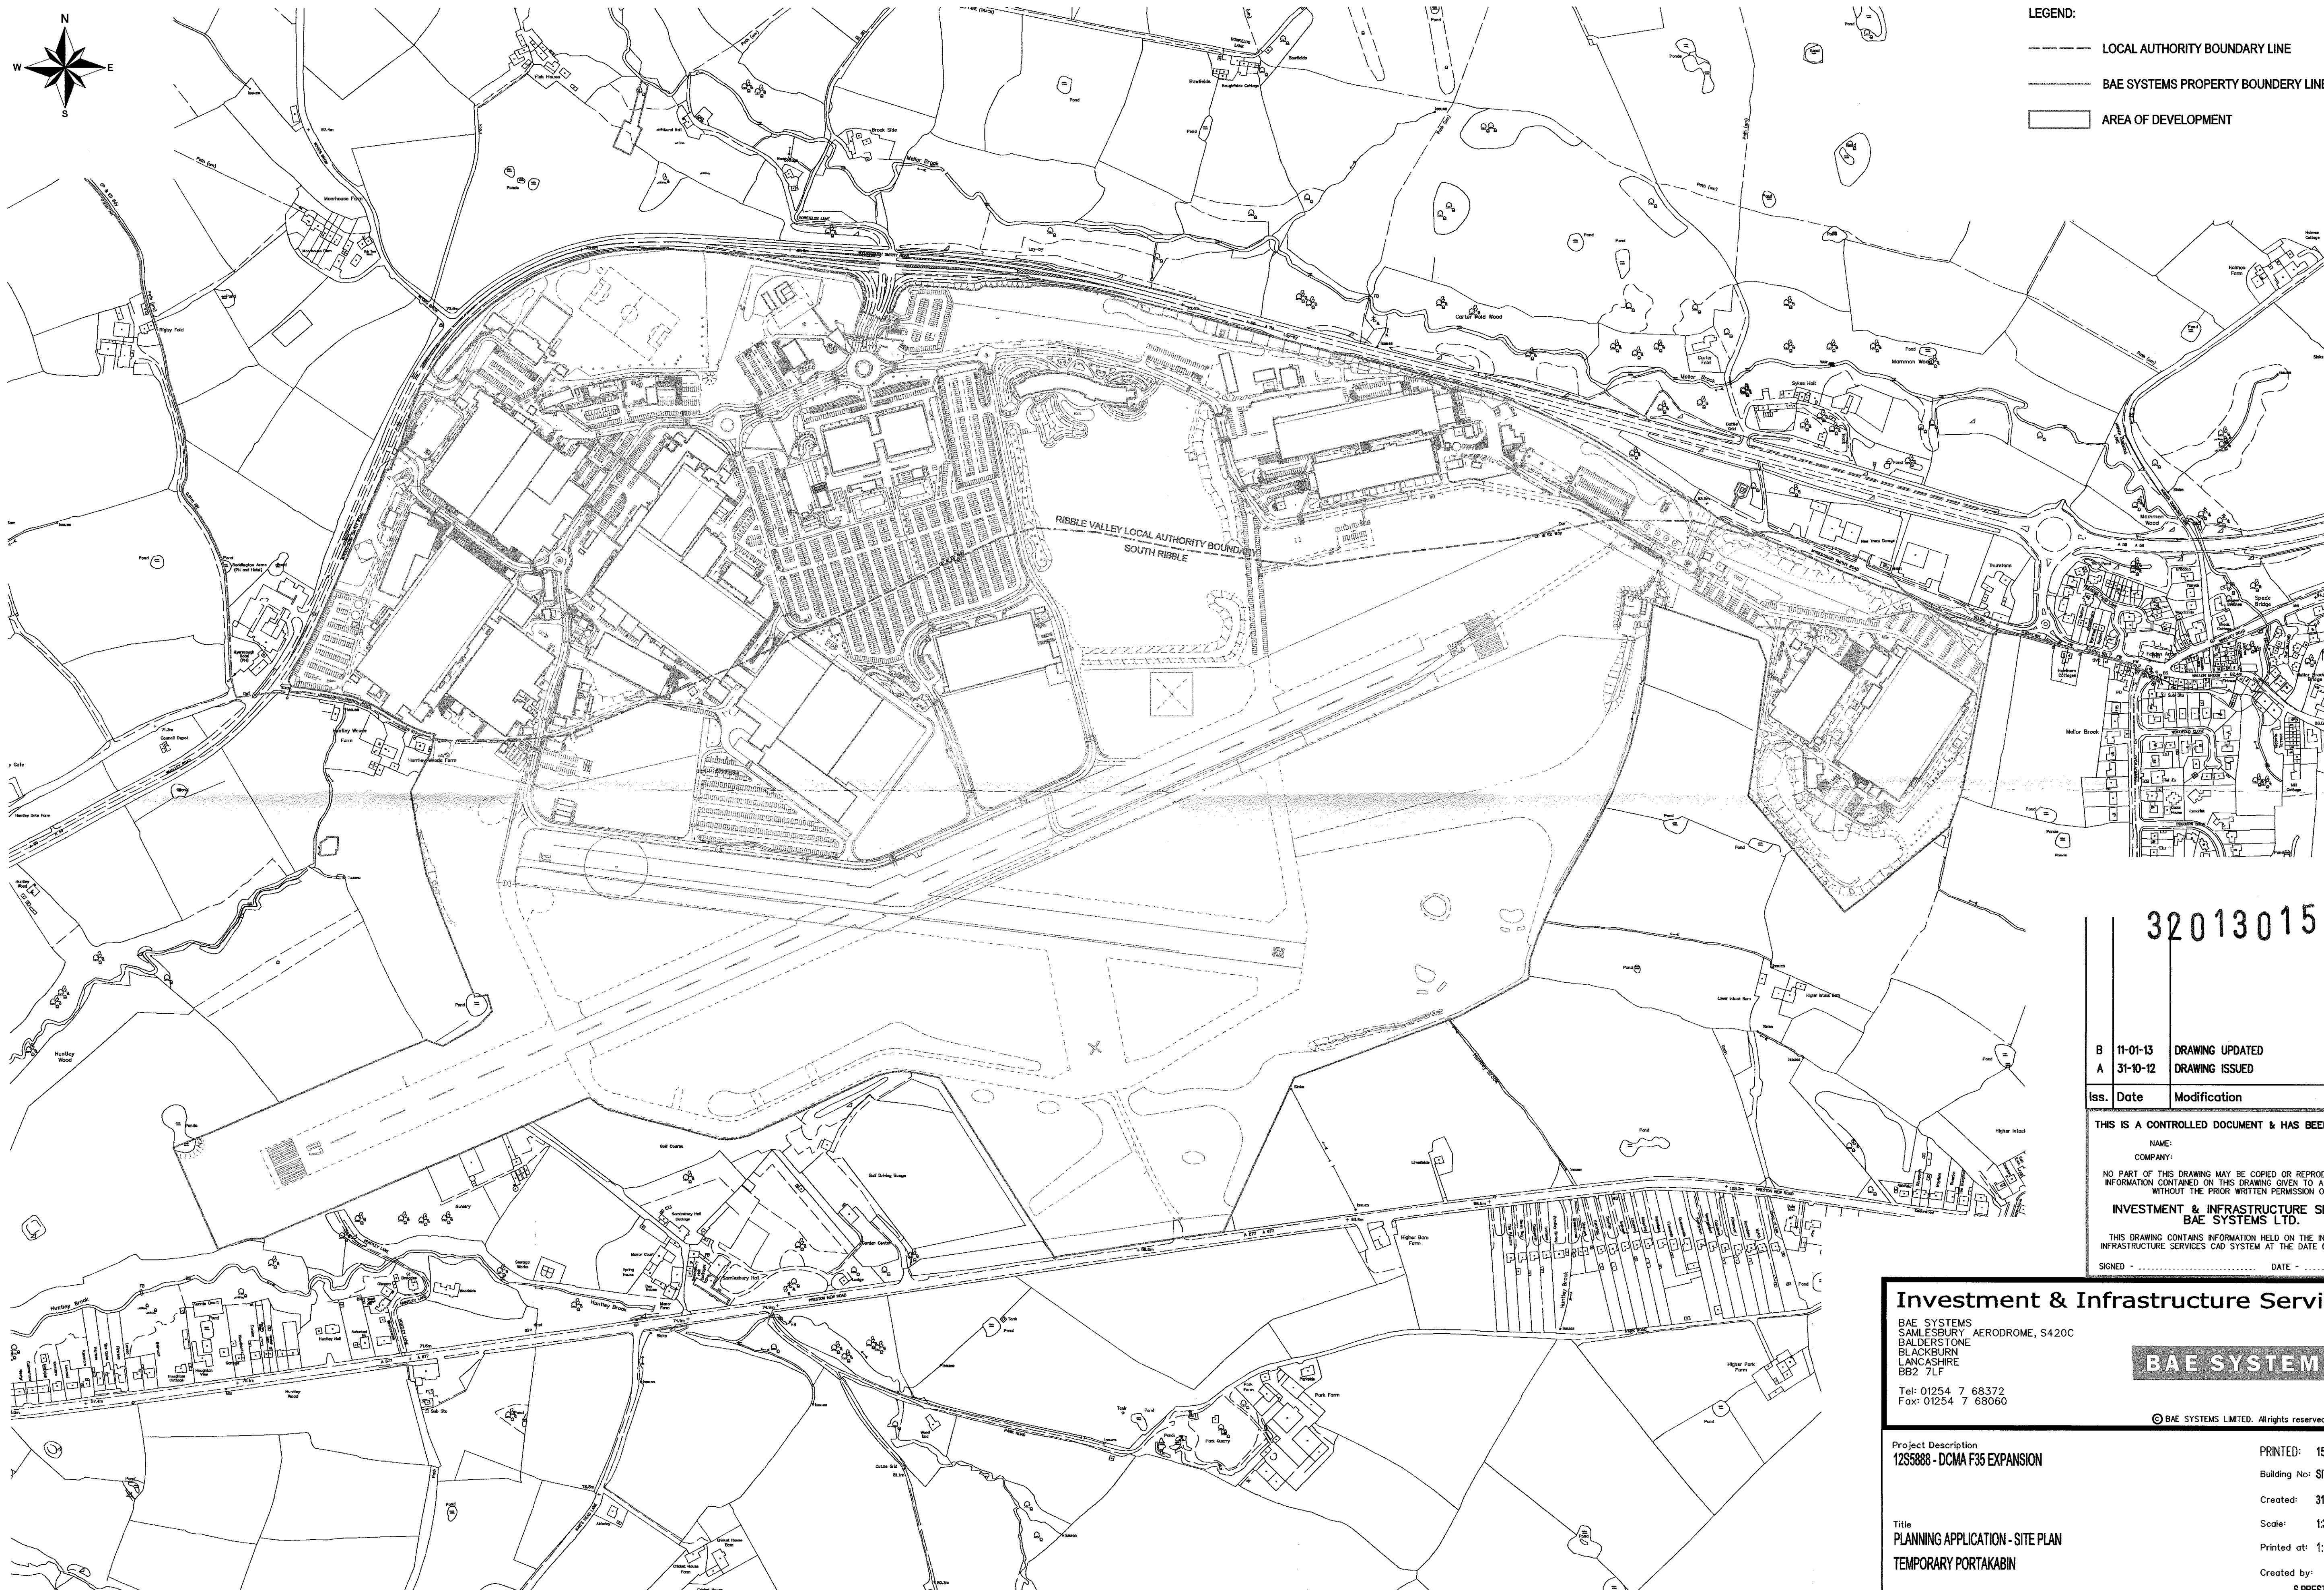

- LEGEND:
- LOCAL AUTHORITY BOUNDARY LINE
 - BAE SYSTEMS PROPERTY BOUNDARY LINE
 - AREA OF DEVELOPMENT

320130151P

B	11-01-13	DRAWING UPDATED	AC
A	31-10-12	DRAWING ISSUED	SP
Iss.	Date	Modification	Init.

THIS IS A CONTROLLED DOCUMENT & HAS BEEN ISSUED TO:

NAME:
COMPANY:

NO PART OF THIS DRAWING MAY BE COPIED OR REPRODUCED OR ANY INFORMATION CONTAINED ON THIS DRAWING GIVEN TO A THIRD PARTY WITHOUT THE PRIOR WRITTEN PERMISSION OF:

INVESTMENT & INFRASTRUCTURE SERVICES
BAE SYSTEMS LTD.

THIS DRAWING CONTAINS INFORMATION HELD ON THE INVESTMENT & INFRASTRUCTURE SERVICES CAD SYSTEM AT THE DATE OF ISSUE ONLY

SIGNED - DATE -

Investment & Infrastructure Services

BAE SYSTEMS
SAMLESSBURY AERODROME, S420C
BLACKBURN
LANCASHIRE
BB2 7LF

Tel: 01254 7 68372
Fax: 01254 7 68060

BAE SYSTEMS


© BAE SYSTEMS LIMITED. All rights reserved.

Project Description
12S5888 - DCMA F35 EXPANSION


Title
PLANNING APPLICATION - SITE PLAN
TEMPORARY PORTAKABIN

PRINTED: 15/01/2013
Building No: SITE
Created: 31/10/12
Scale: 1:3500 @ A1
Printed at: 1:3500 m/mm
Created by: S PRESTON





Project No. **12S5888 / 002** Issue **B**

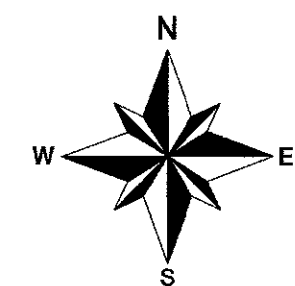

PLAN VIEW
SCALE 1:250

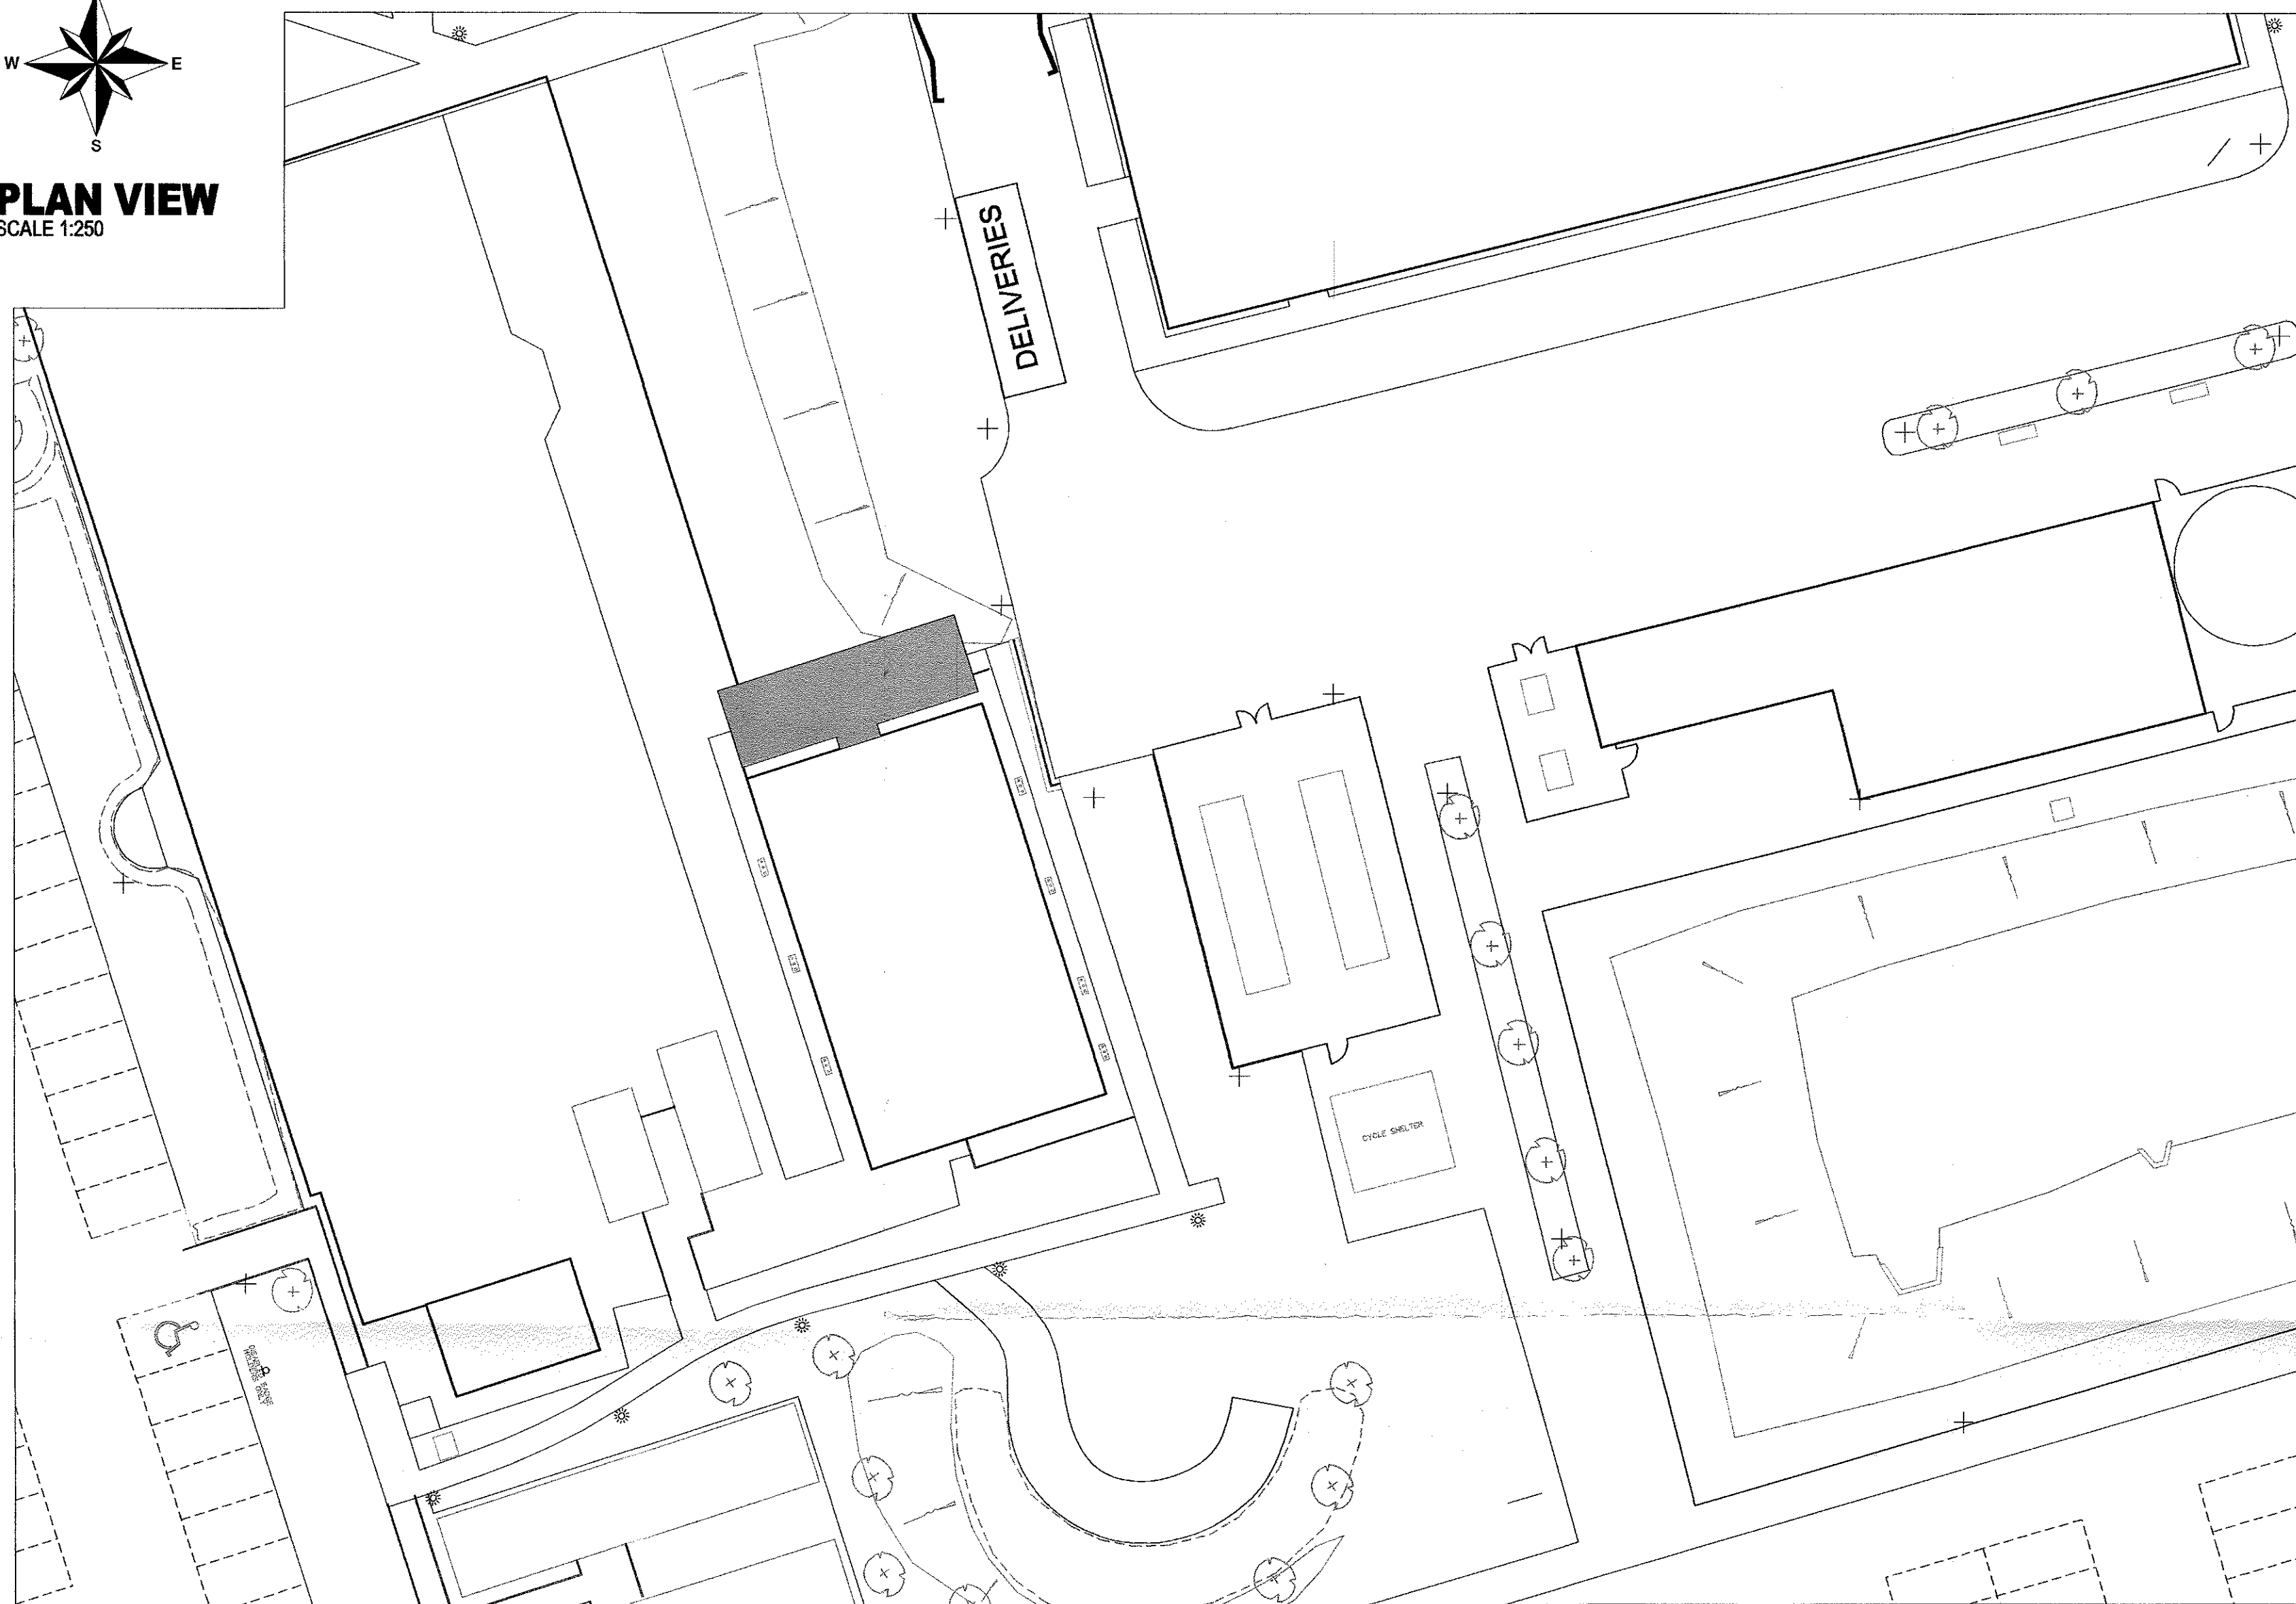

BUILDING PLAN & ELEVATIONS
SCALE 1:100

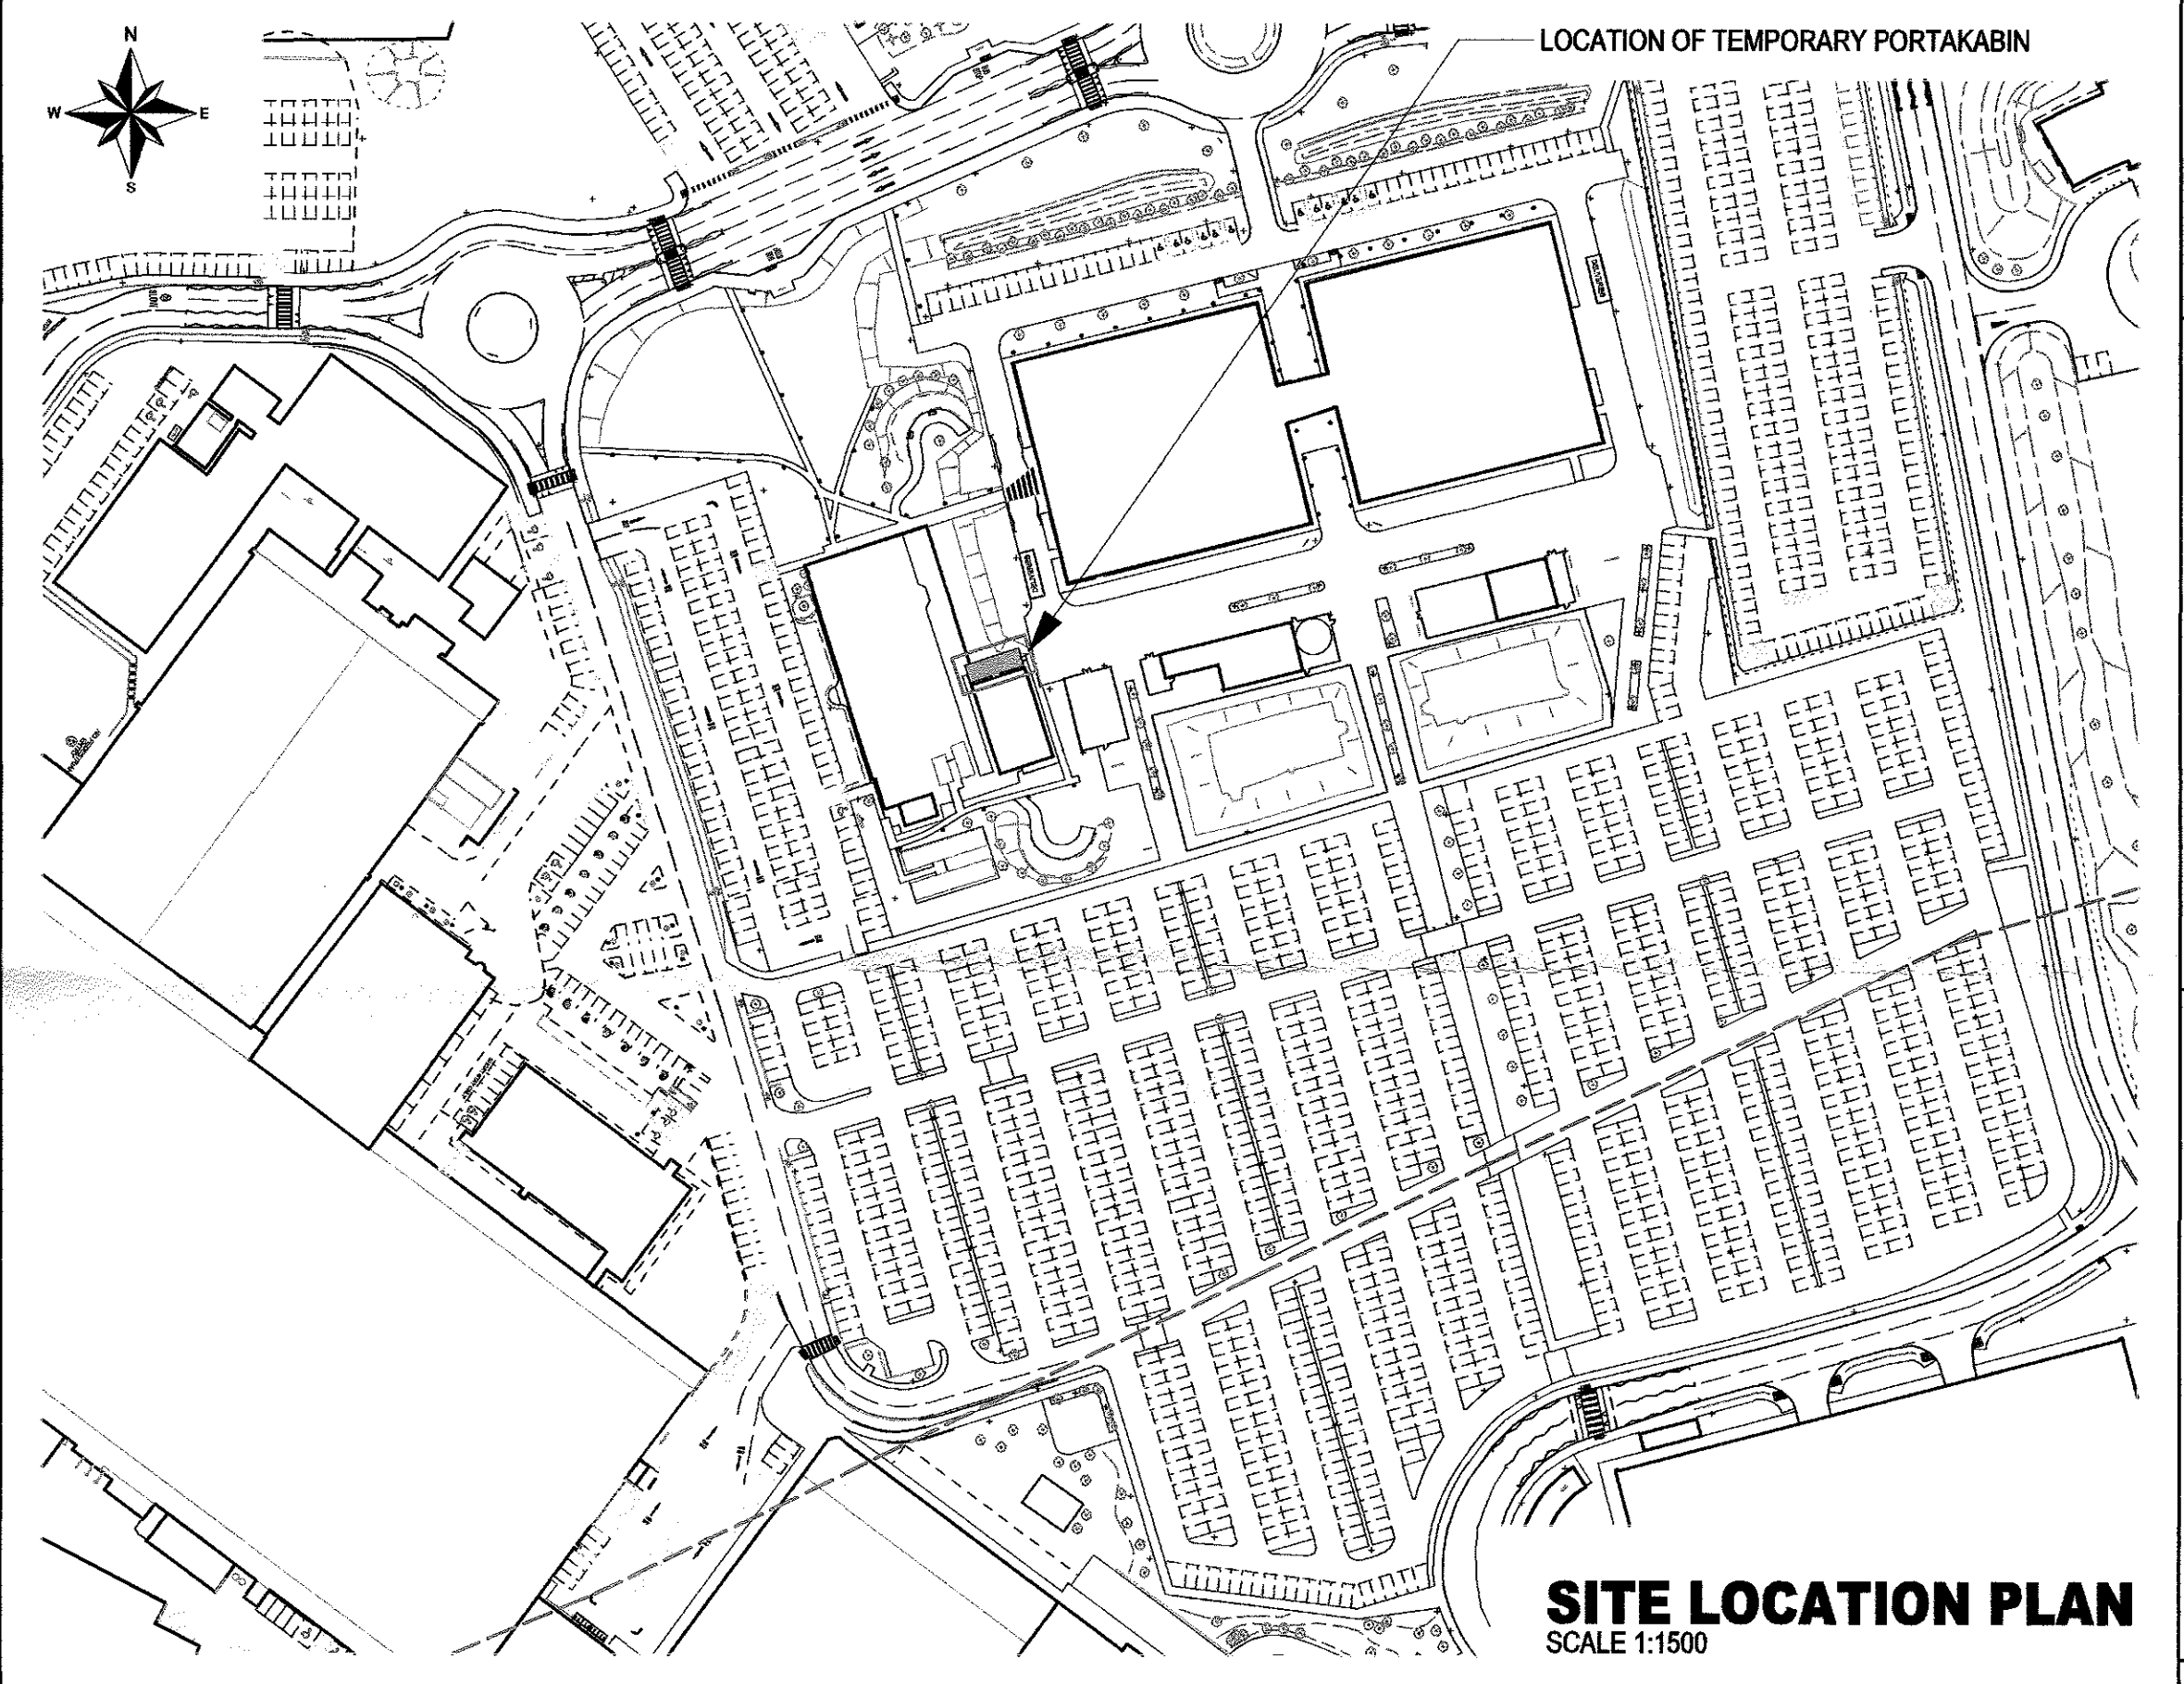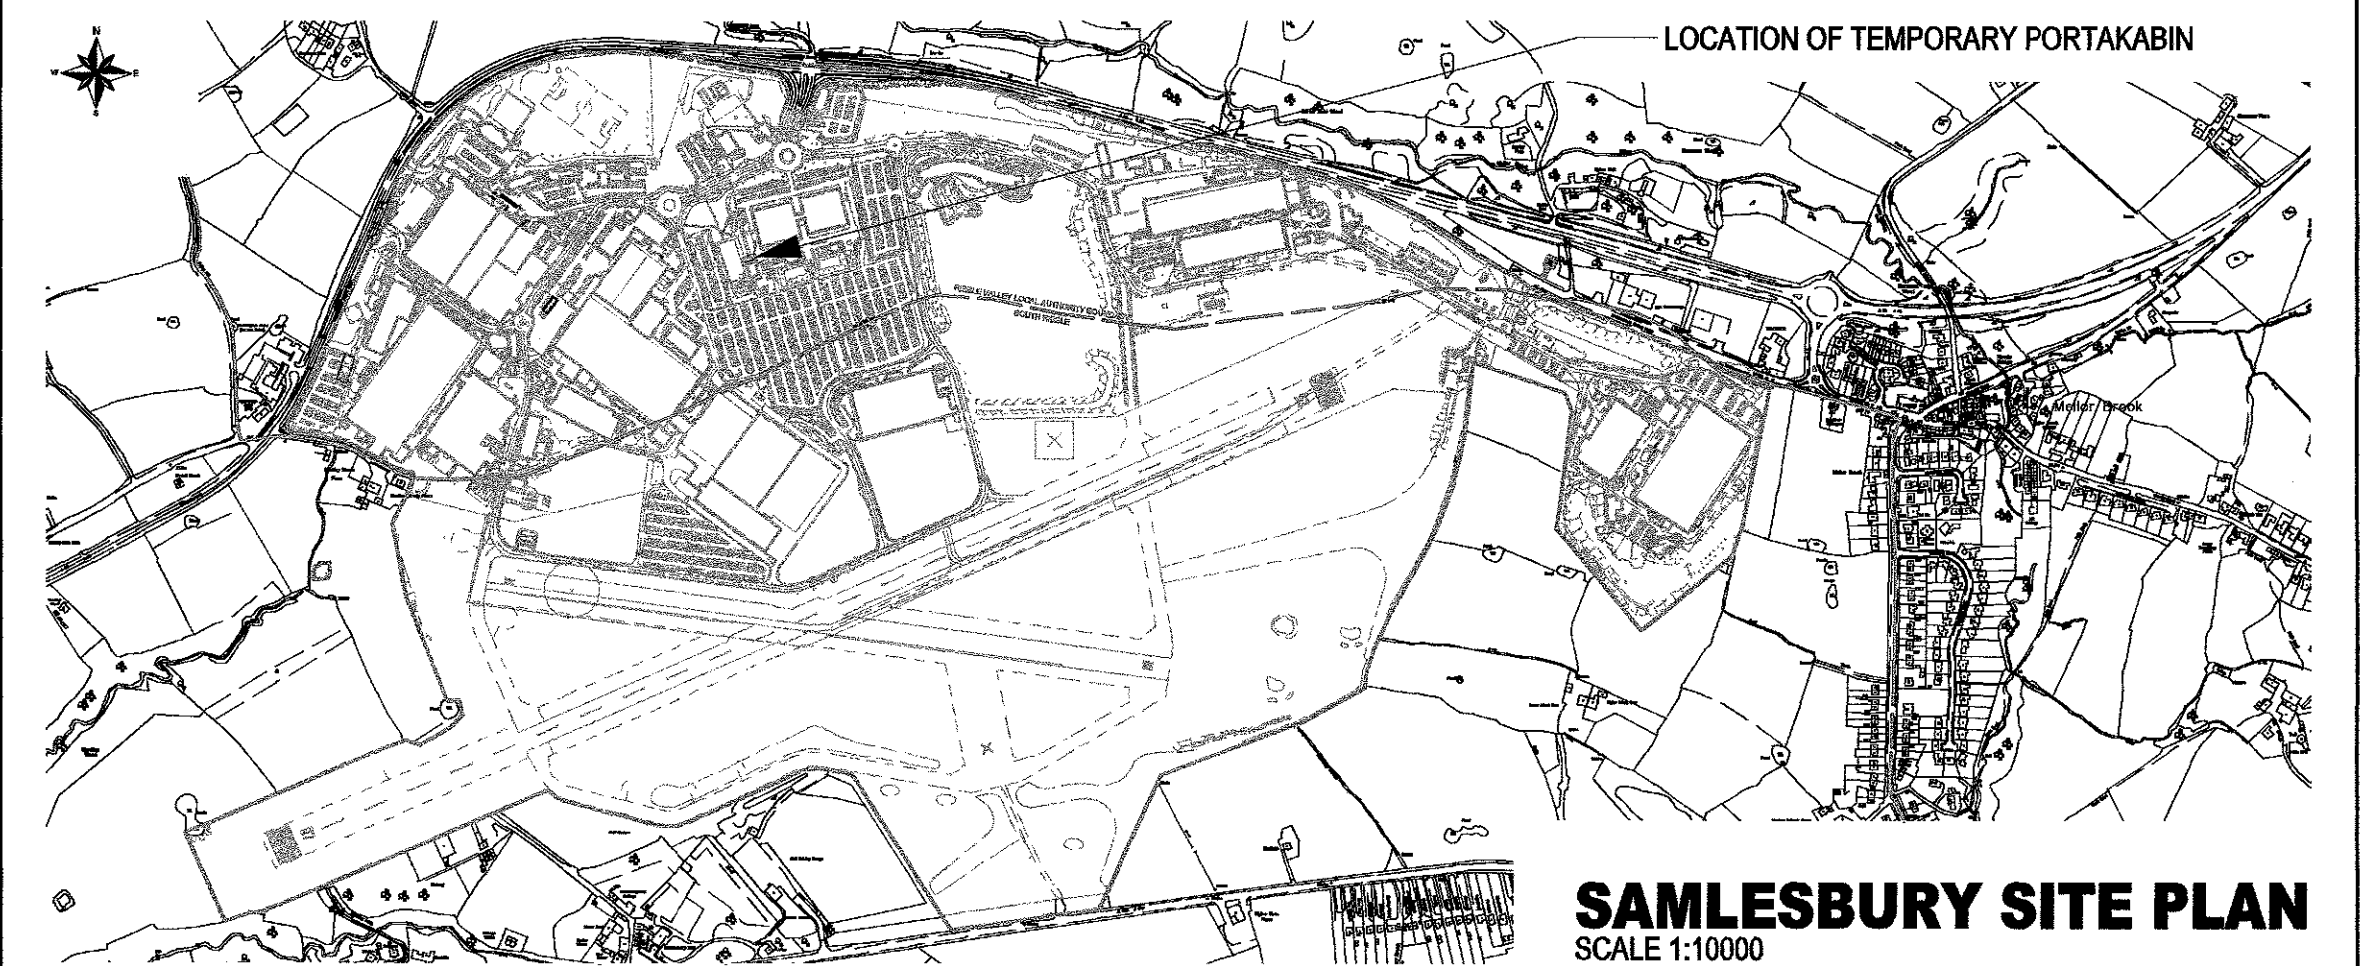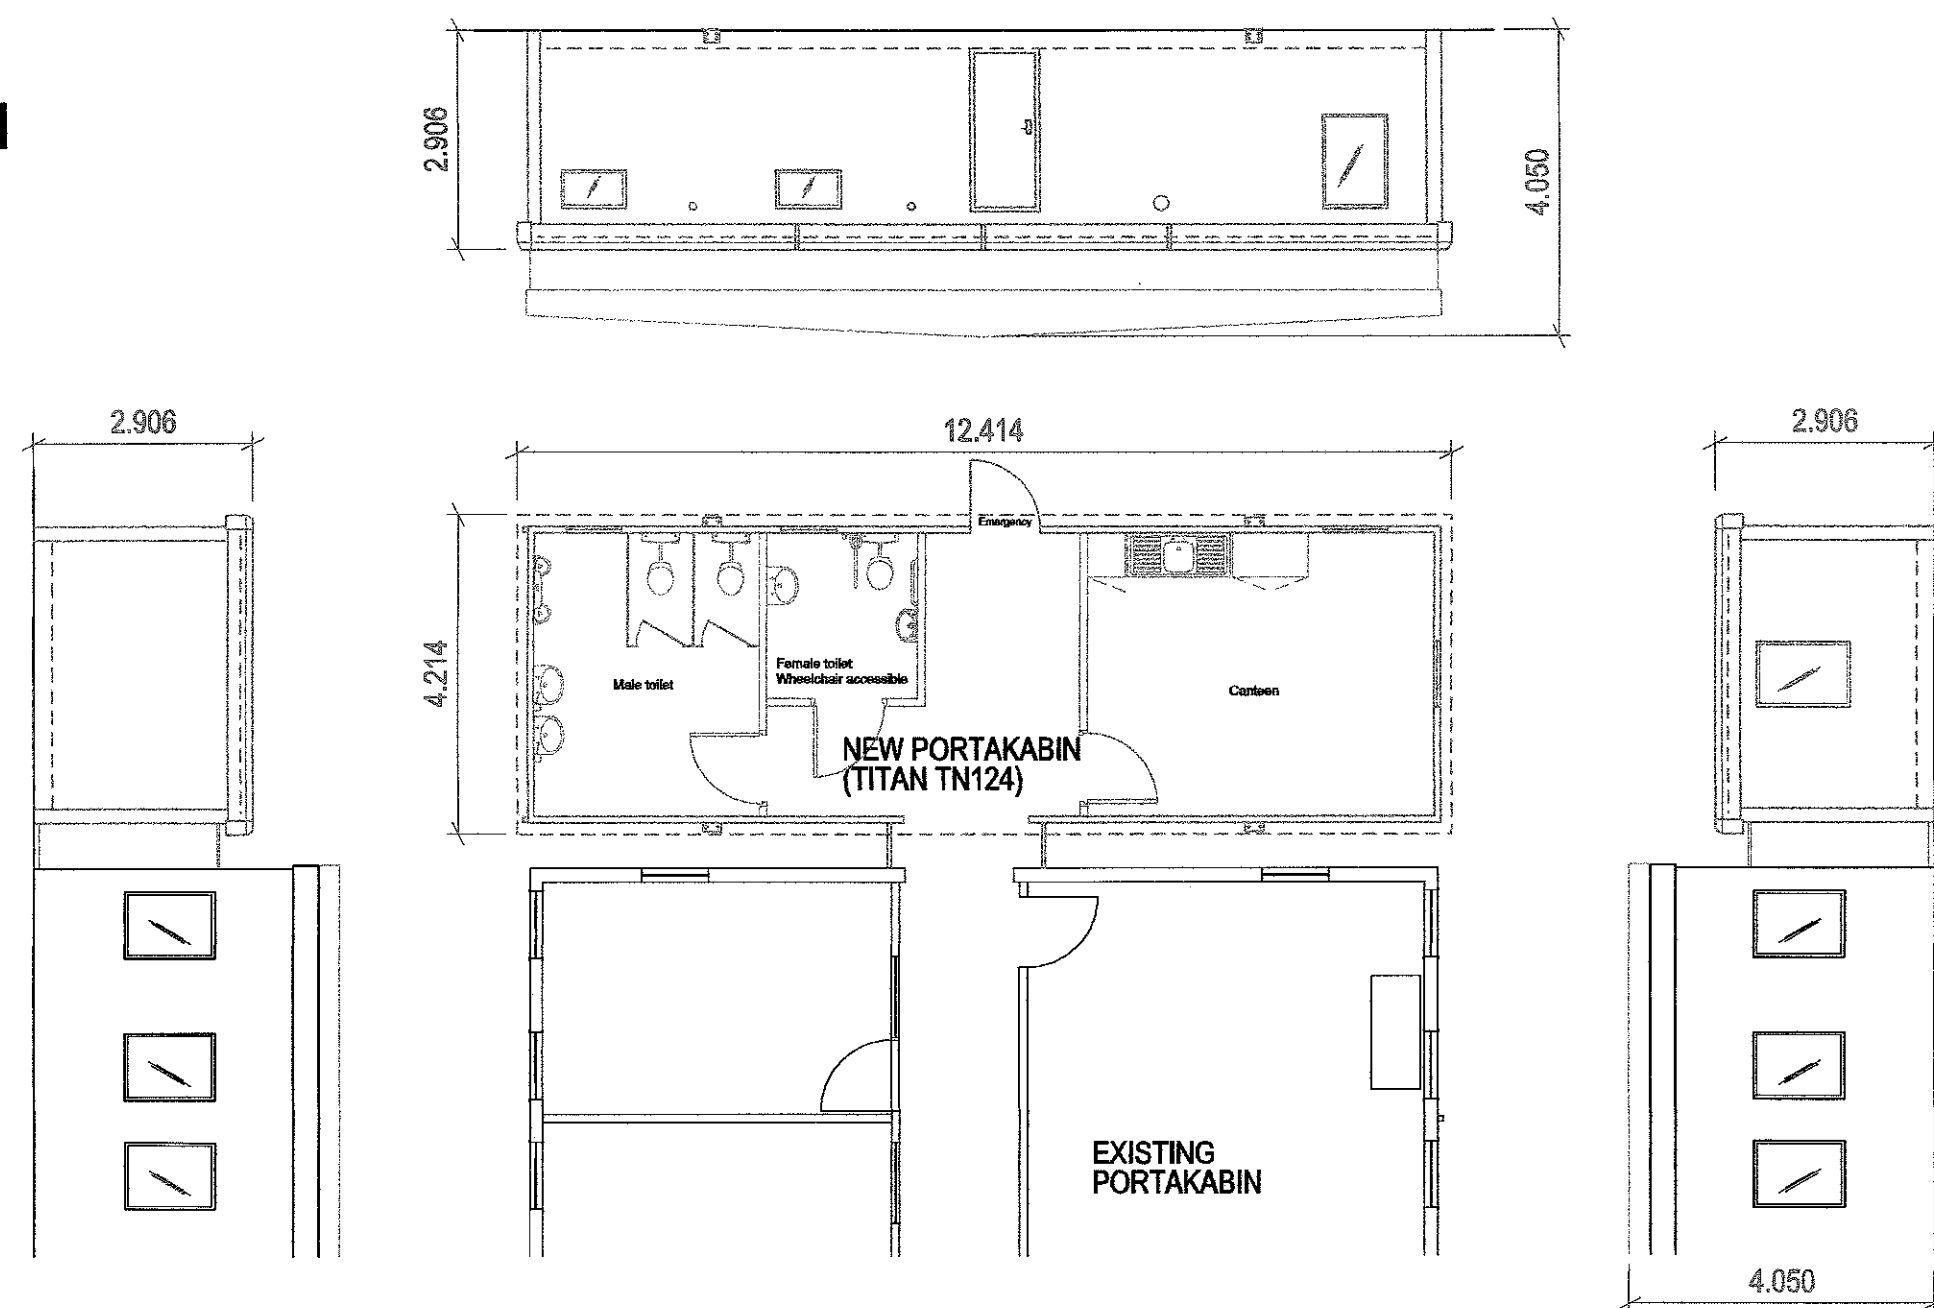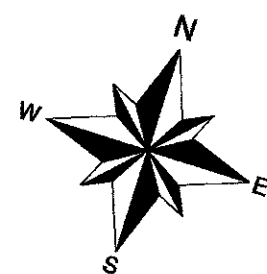

320130151P


THIS IS A CONTROLLED DOCUMENT & HAS BEEN ISSUED TO:
NAME:
COMPANY:
NO PART OF THIS DRAWING MAY BE COPIED OR REPRODUCED OR ANY INFORMATION CONTAINED ON THIS DRAWING GIVEN TO A THIRD PARTY WITHOUT THE PRIOR WRITTEN PERMISSION OF:
INVESTMENT & INFRASTRUCTURE SERVICES
BAE SYSTEMS LTD.
THIS DRAWING CONTAINS INFORMATION HELD ON THE INVESTMENT & INFRASTRUCTURE SERVICES CAD SYSTEM AT THE DATE OF ISSUE ONLY
SIGNED - DATE -

Investment & Infrastructure Services
BAE SYSTEMS
SAMBLESBURY AERODROME, S420C
BALDERSTONE
BLACKBURN
LANCASHIRE
BB2 7LF
Tel: 01254 7 68372
Fax: 01254 7 68060
© BAE SYSTEMS LIMITED. All rights reserved.

Project Description
12S5888 - DCMA F35 EXPANSION
Building No: 417
Created: 31/10/12
Scale: 1:250 @ A1
Printed at: 1:0.250 m / mm
Created by:
S PRESTON
Project No.
12S5888 / 003
Issue
B

B	11-01-13	DRAWING UPDATED
A	31-10-12	DRAWING ISSUED
Iss.	Date	Modification

AC
SP
Init.

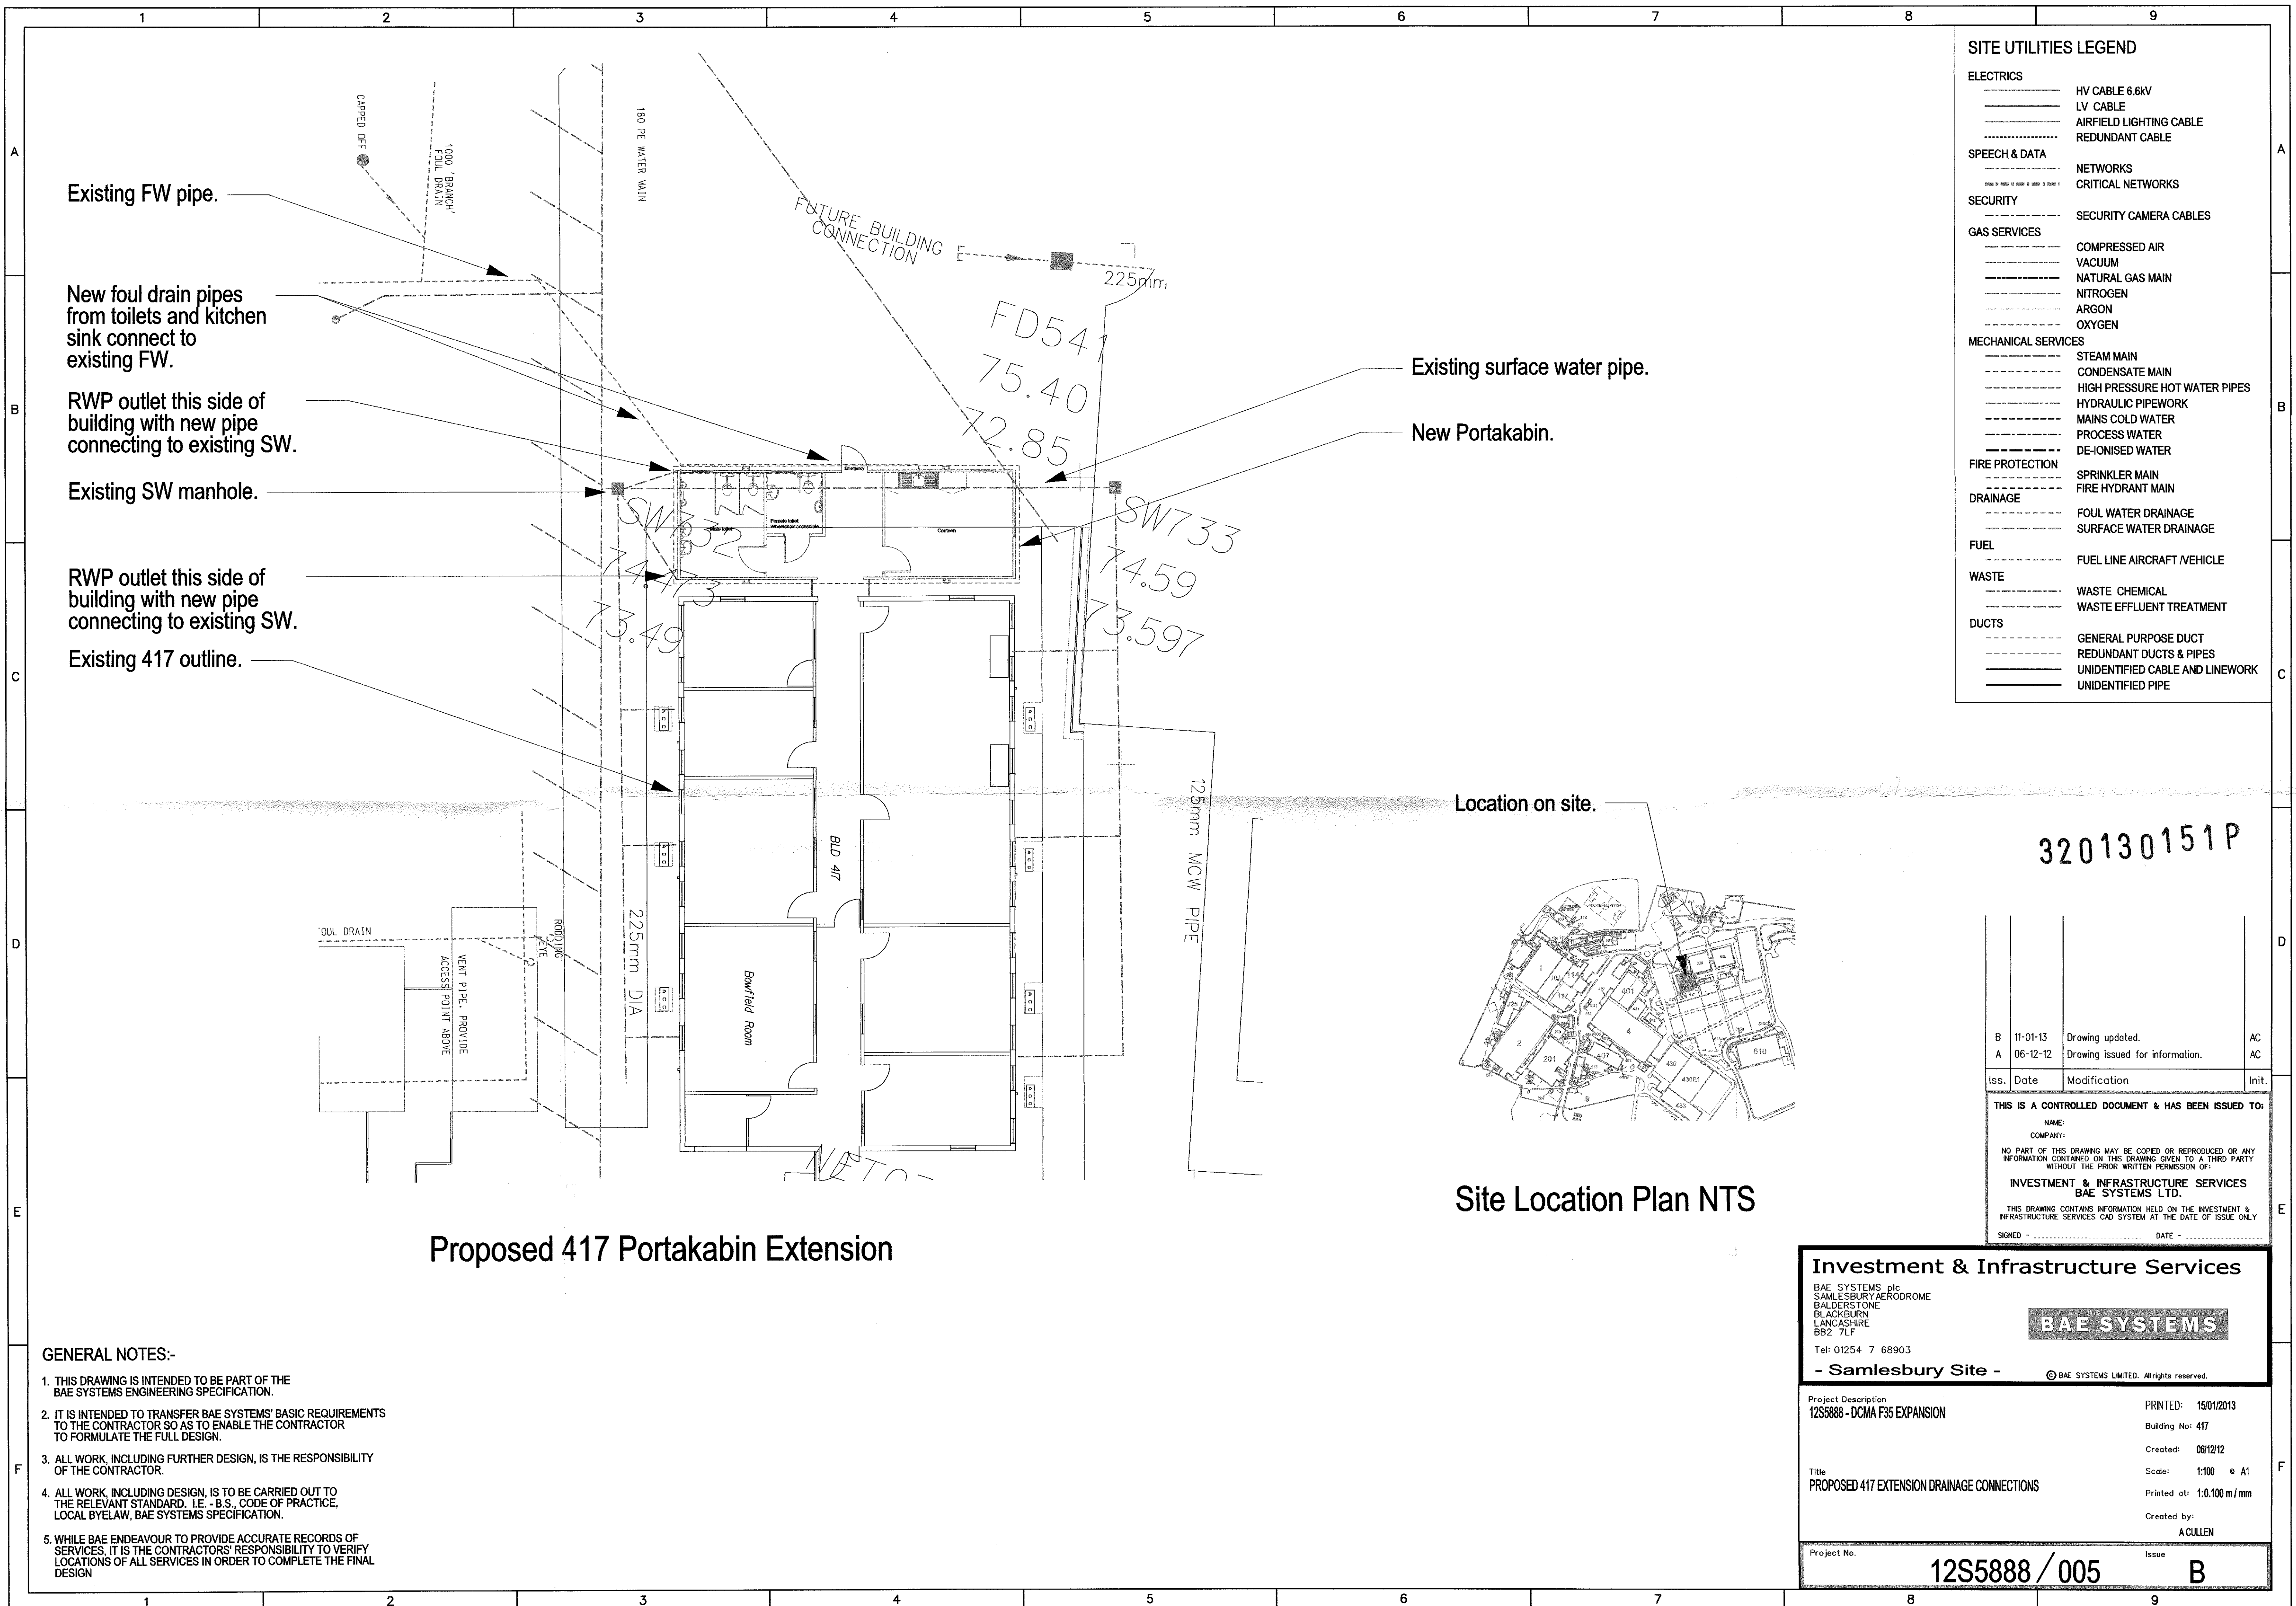

SITE UTILITIES LEGEND	
ELECTRICS	HV CABLE 6.6KV
	LV CABLE
	AIRFIELD LIGHTING CABLE
	REDUNDANT CABLE
SPEECH & DATA	NETWORKS
	CRITICAL NETWORKS
SECURITY	SECURITY CAMERA CABLES
GAS SERVICES	COMPRESSED AIR
	VACUUM
	NATURAL GAS MAIN
	NITROGEN
	ARGON
	OXYGEN
MECHANICAL SERVICES	STEAM MAIN
	CONDENSATE MAIN
	HIGH PRESSURE HOT WATER PIPES
	HYDRAULIC PIPEWORK
	MAINS COLD WATER
	PROCESS WATER
	DE-IONISED WATER
FIRE PROTECTION	SPRINKLER MAIN
	FIRE HYDRANT MAIN
DRAINAGE	FOUL WATER DRAINAGE
	SURFACE WATER DRAINAGE
FUEL	FUEL LINE AIRCRAFT /VEHICLE
WASTE	WASTE CHEMICAL
	WASTE EFFLUENT TREATMENT
DUCTS	GENERAL PURPOSE DUCT
	REDUNDANT DUCTS & PIPES
	UNIDENTIFIED CABLE AND LINWORK
	UNIDENTIFIED PIPE

320130151P			
B	11-01-13	Drawing updated.	AC
A	06-12-12	Drawing issued for information.	AC
Iss.	Date	Modification	Init.
THIS IS A CONTROLLED DOCUMENT & HAS BEEN ISSUED TO:			
NAME:			
COMPANY:			
NO PART OF THIS DRAWING MAY BE COPIED OR REPRODUCED OR ANY INFORMATION CONTAINED ON THIS DRAWING GIVEN TO A THIRD PARTY WITHOUT THE PRIOR WRITTEN PERMISSION OF:			
INVESTMENT & INFRASTRUCTURE SERVICES			
BAE SYSTEMS LTD.			
THIS DRAWING CONTAINS INFORMATION HELD ON THE INVESTMENT & INFRASTRUCTURE SERVICES CAD SYSTEM AT THE DATE OF ISSUE ONLY			
SIGNED -		DATE -	

Site Location Plan NTS

Proposed 417 Portakabin Extension

- GENERAL NOTES:-
- THIS DRAWING IS INTENDED TO BE PART OF THE BAE SYSTEMS ENGINEERING SPECIFICATION.
 - IT IS INTENDED TO TRANSFER BAE SYSTEMS' BASIC REQUIREMENTS TO THE CONTRACTOR SO AS TO ENABLE THE CONTRACTOR TO FORMULATE THE FULL DESIGN.
 - ALL WORK, INCLUDING FURTHER DESIGN, IS THE RESPONSIBILITY OF THE CONTRACTOR.
 - ALL WORK, INCLUDING DESIGN, IS TO BE CARRIED OUT TO THE RELEVANT STANDARD, I.E. - B.S., CODE OF PRACTICE, LOCAL BYELAW, BAE SYSTEMS SPECIFICATION.
 - WHILE BAE ENDEAVOUR TO PROVIDE ACCURATE RECORDS OF SERVICES, IT IS THE CONTRACTORS' RESPONSIBILITY TO VERIFY LOCATIONS OF ALL SERVICES IN ORDER TO COMPLETE THE FINAL DESIGN

Investment & Infrastructure Services

BAE SYSTEMS plc
SAMESBURY AERODROME
BALDERSTONE
BLACKBURN
LANCASHIRE
BB2 7LF
Tel: 01254 7 68903

- Samlesbury Site -

Project Description
12S5888 - DCMA F35 EXPANSION

PRINTED: 15/01/2013
Building No: 417
Created: 08/12/12
Scale: 1:100 @ A1
Printed at: 1:0.100 m/mm
Created by:
A CULLEN

Project No.

12S5888 / 005

Issue

B