


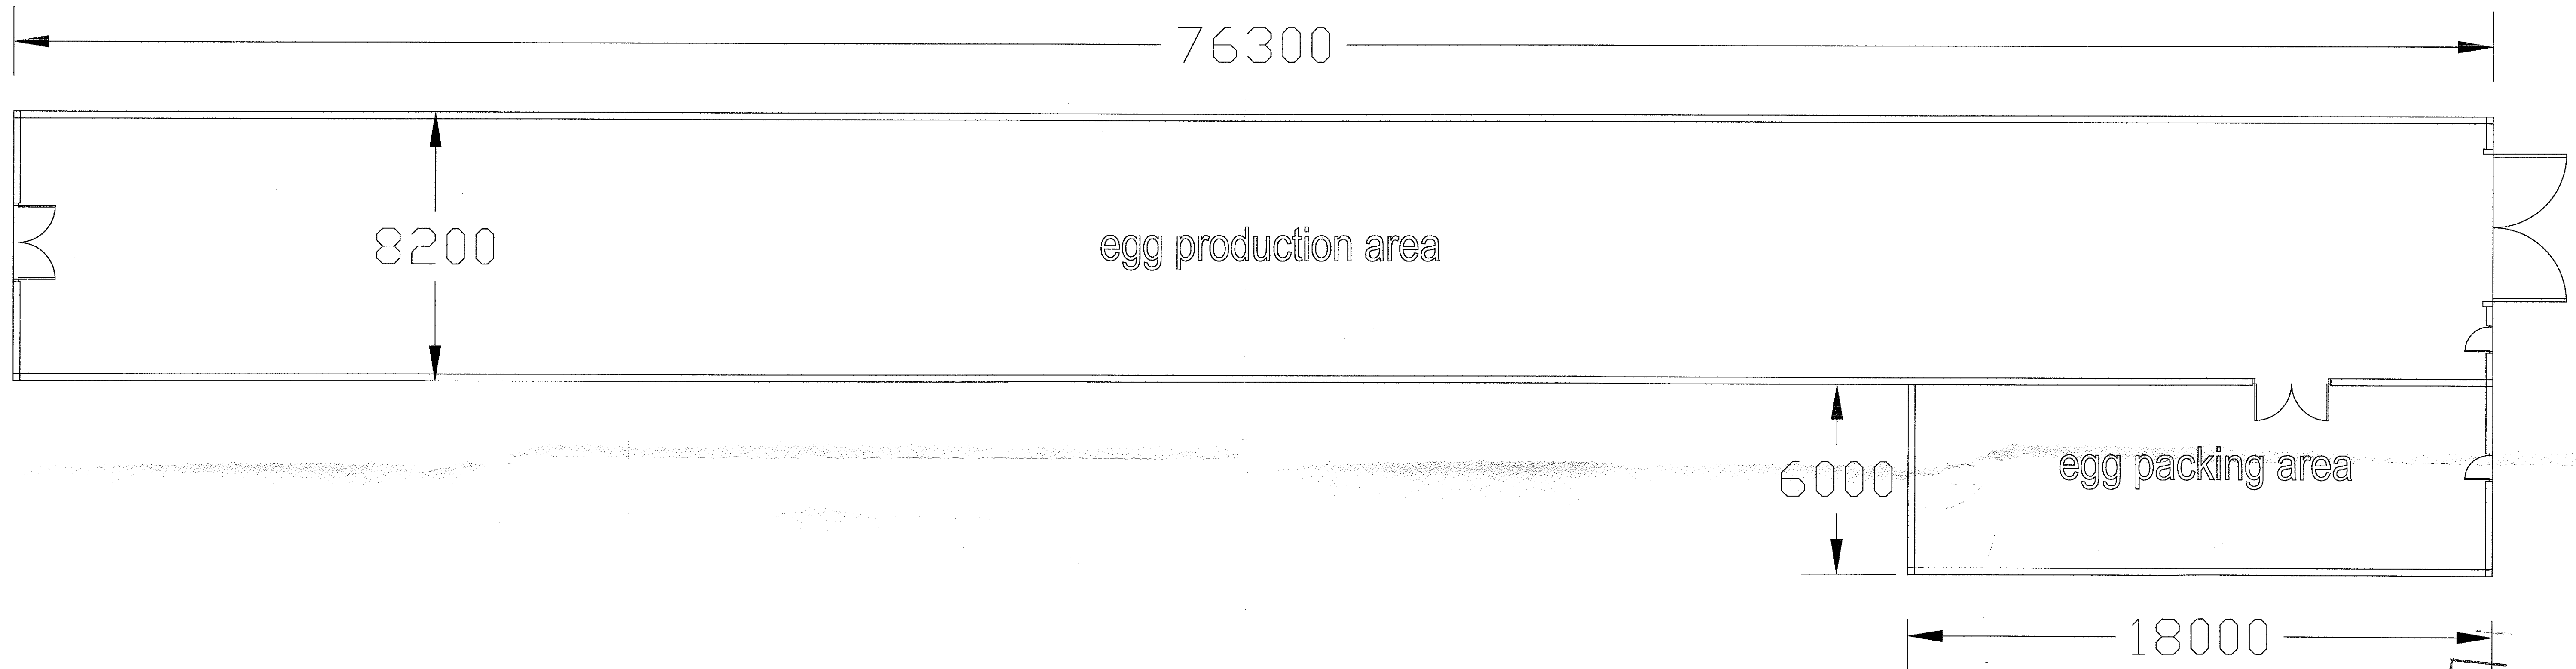

floor plan

scale 1:200

03 MAR 2016
FOR THE
ATTENTION OF

proposed poultry unit at
Longsight Road
Clayton-le-Dale

Proposed Floor Plans

drawing number
RC/23/07/13/A

0m 10m
linear scale 1:100 @ A1

Rae Connell Associates Building Design and Planning Consultants
214 Burnley Road Bacup Lancashire 01706 873000