




FIRE HYDRANT AND MAIN SUPPLY
RELOCATED

DO NOT SCALE


FAN + NO
ABATEMENT

320130484P


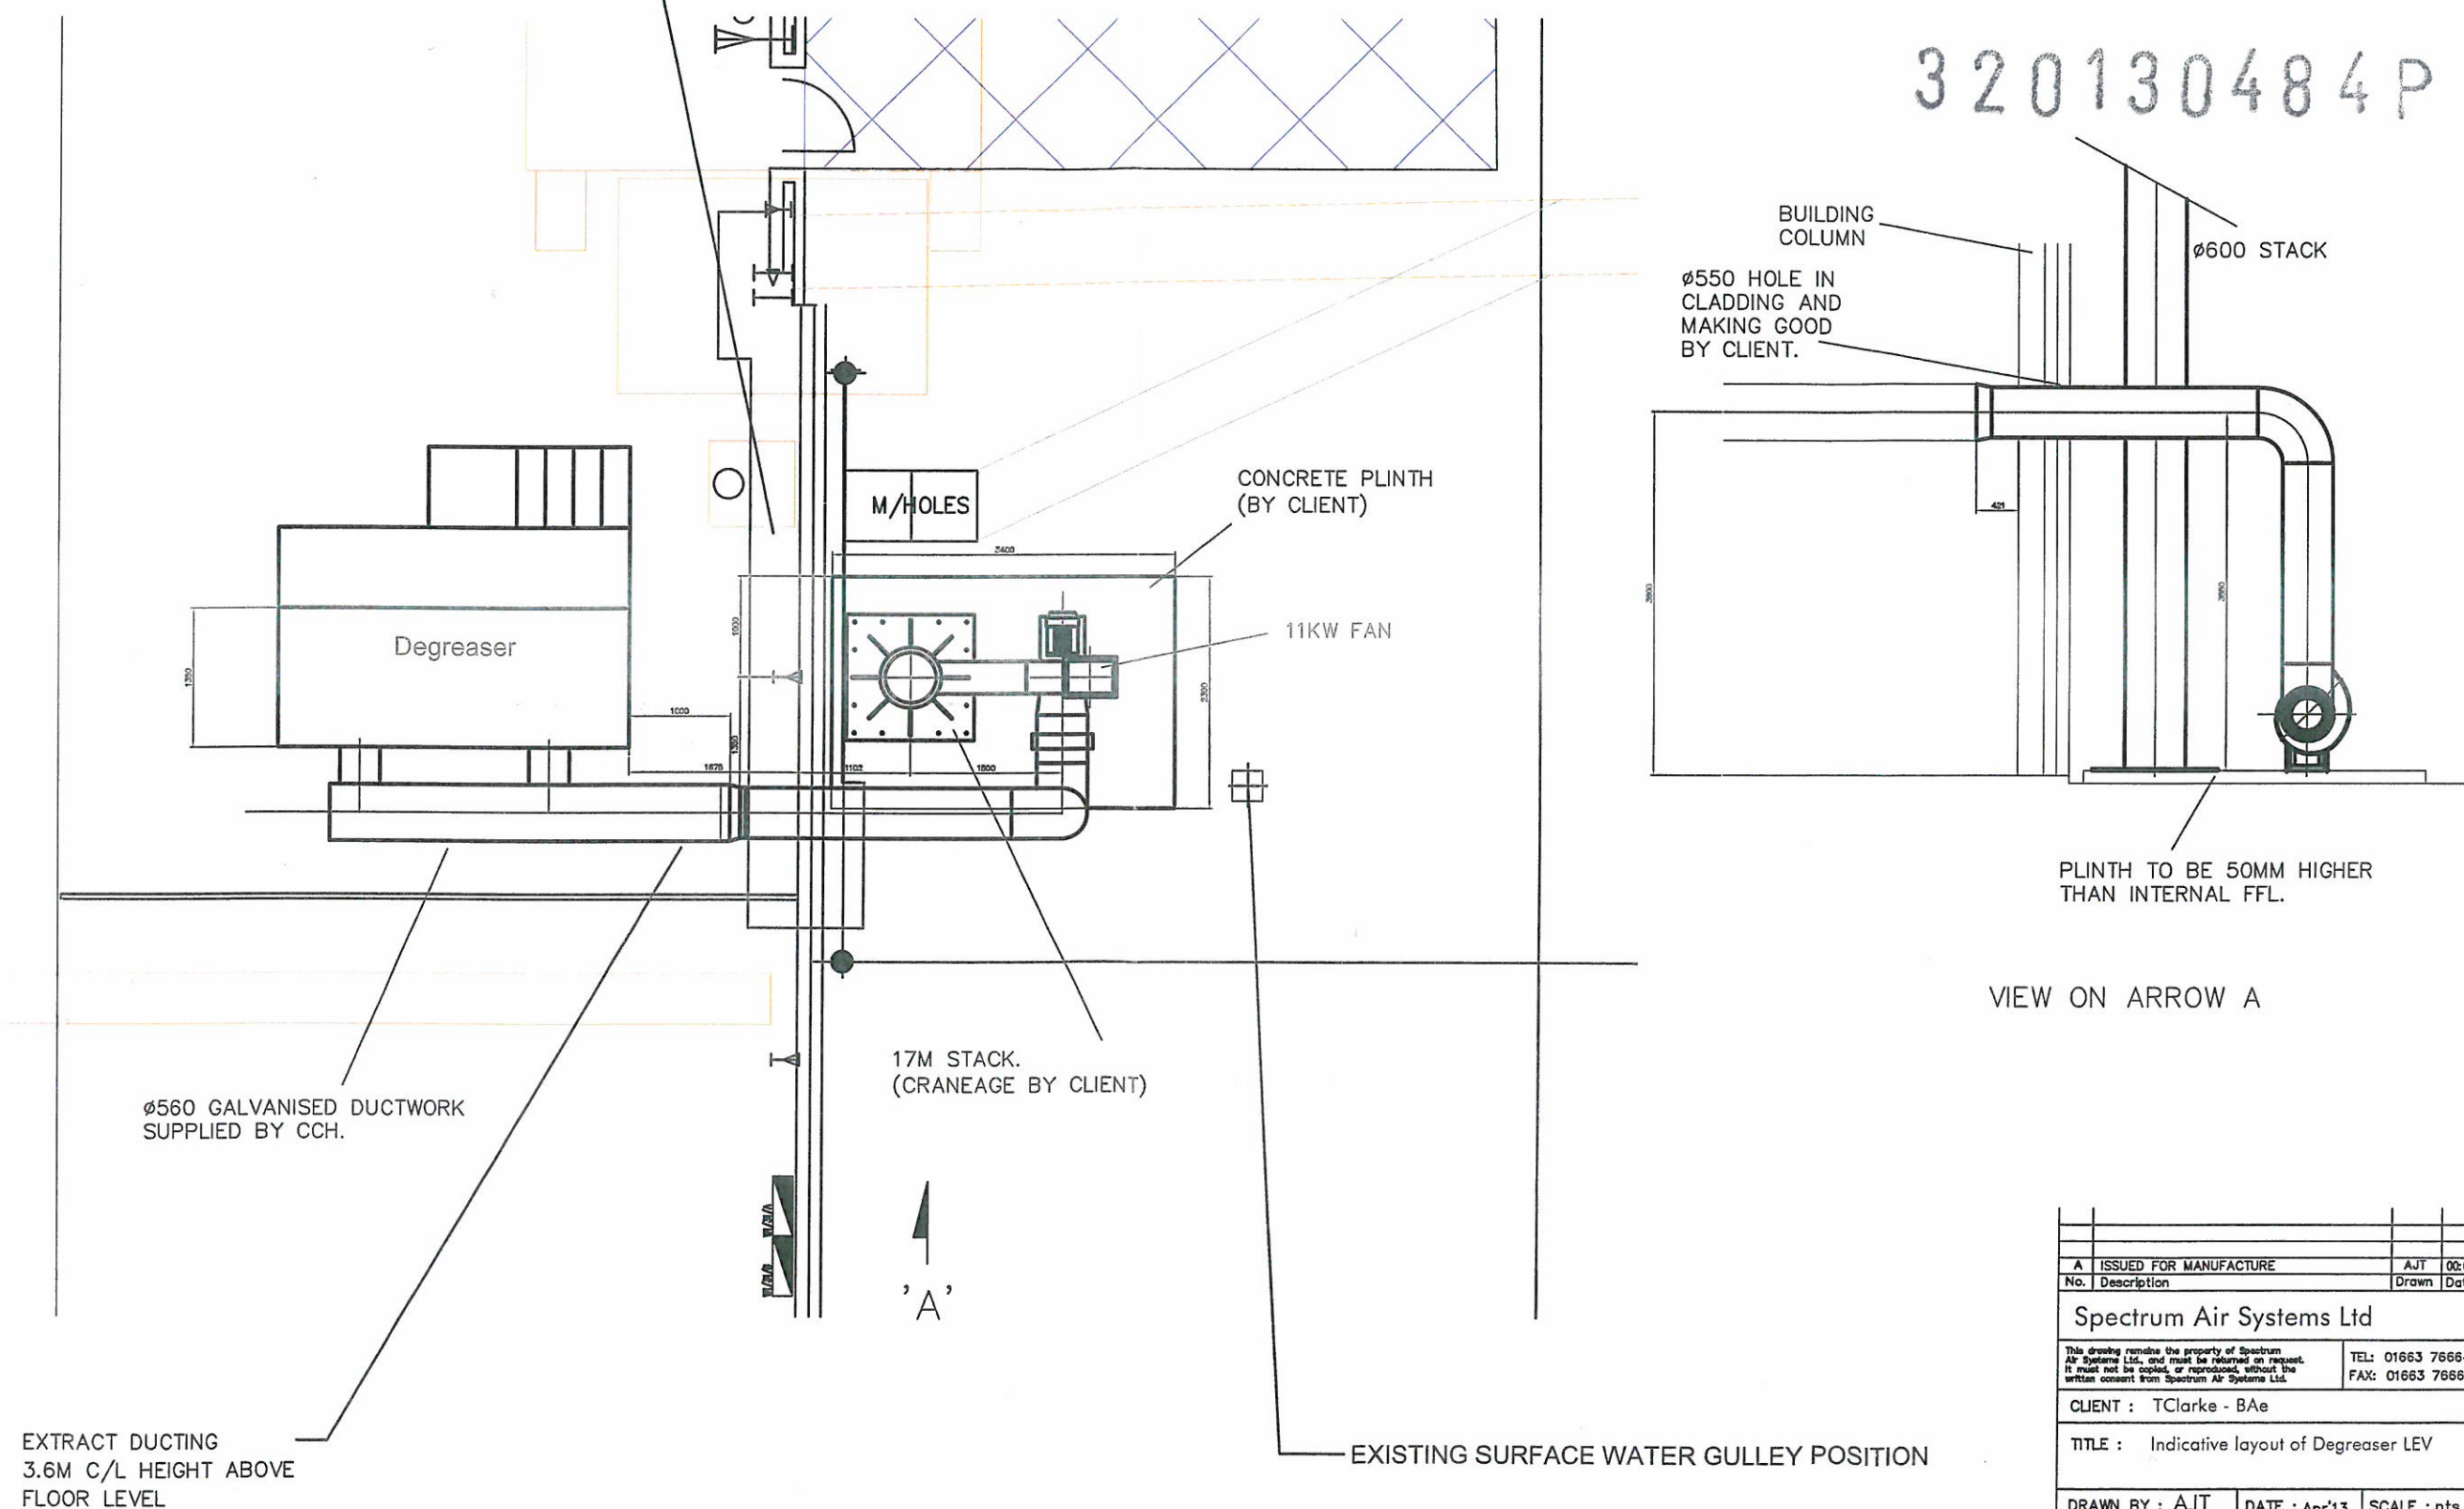


A	ISSUED FOR MANUFACTURE	AJT	00:00:00
No.	Description	Drawn	Date
Spectrum Air Systems Ltd			
This drawing remains the property of Spectrum Air Systems Ltd, and must be returned on request. It must not be copied, or reproduced, without the written consent from Spectrum Air Systems Ltd.		TEL: 01663 766644 FAX: 01663 766699	
CLIENT : TClarke - BAe			
TITLE : Indicative layout of Degreaser LEV			
DRAWN BY : AJT		DATE : Apr'13	SCALE : nts
CHECKED BY :		DATE :	
DRAWING No : 15113-04-CL			REV A

DO NOT SCALE

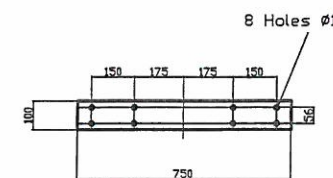

Enlarged view of the drilling details on mounting face of the Stack Bracket

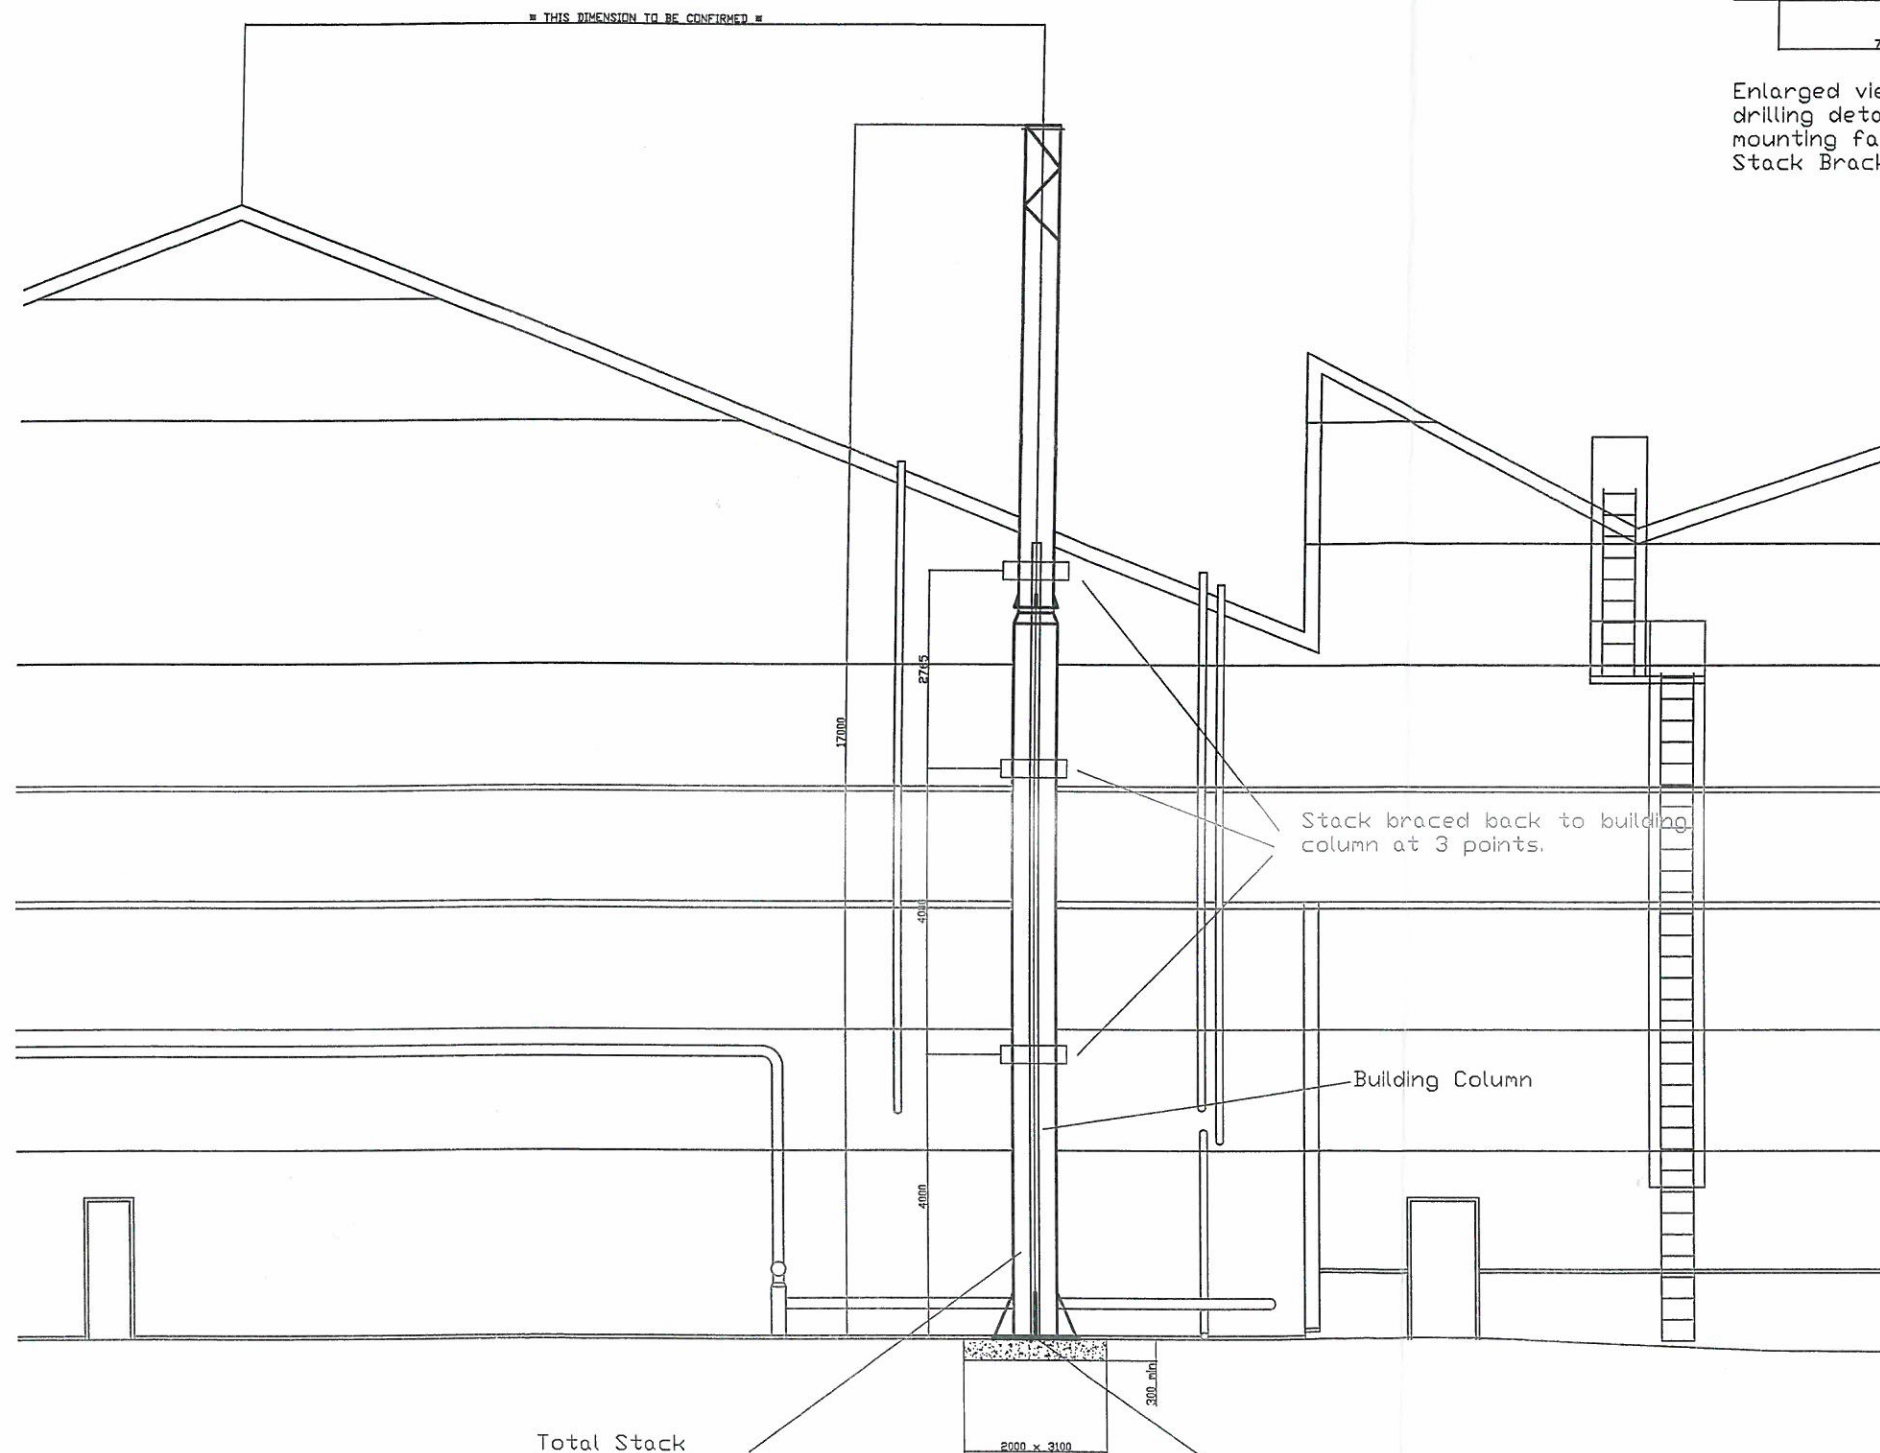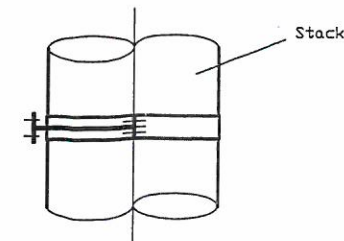

Total Stack Weight = 1500 kg

Stack centerline to be 850 from face of building

Others to supply support steels (3 off) from building column to Stack Bracket. See enlarged view for drilling details.

Building Column

Gas Main

Static Fan Weight = 200 kg

Suitable concrete plinth by client.

1 SHED WEST ELEVATION

A	ISSUED FOR APPROVAL	AJT	0000
No.	Description	Drawn	Date
Spectrum Air Systems Ltd			
This drawing remains the property of Spectrum Air Systems Ltd, and must be returned on request. It must not be copied, or reproduced, without the written consent from Spectrum Air Systems Ltd.		TEL: 01663 7666 FAX: 01663 7666	
CLIENT : TClarke - BAe			
TITLE : Provisional Stack Layout No. 1 Shed			
DRAWN BY : AJT		DATE : Apr'13	SCALE : 1/5
CHECKED BY :		DATE :	
DRAWING No : 15113-01			REV A

SITE PLAN

320130484P

LOCAL AREA PLAN

T.Clarke North West Ltd.
JUNCTION 7 BUSINESS PARK,
BLACKBURN ROAD,
CLAYTON-LE-MOORS,
ACCRINGTON,
LANCASHIRE
BB5 5JW

TClarke

© T.Clarke North West Ltd. All rights reserved.

CLIENT:

BAE SYSTEMS

© BAE SYSTEMS LIMITED. All rights reserved.

PROJECT:
No1 SHED - ADVANCED FORMING AND ASSEMBLY FACILITY
BROUGH TRANSITIONS

TITLE:
PIPES DEGREASING AREA

BAE PROJECT NO:

SCALE	Drawn	APPROVED	DATE
N.T.S	P.R.A	M.S	26-04-13
DRAWING NO.	REFERENCE DRAWING NO.		REV
TC00104-1250079-104			
DES. STATUS:	PROPOSAL		