
 


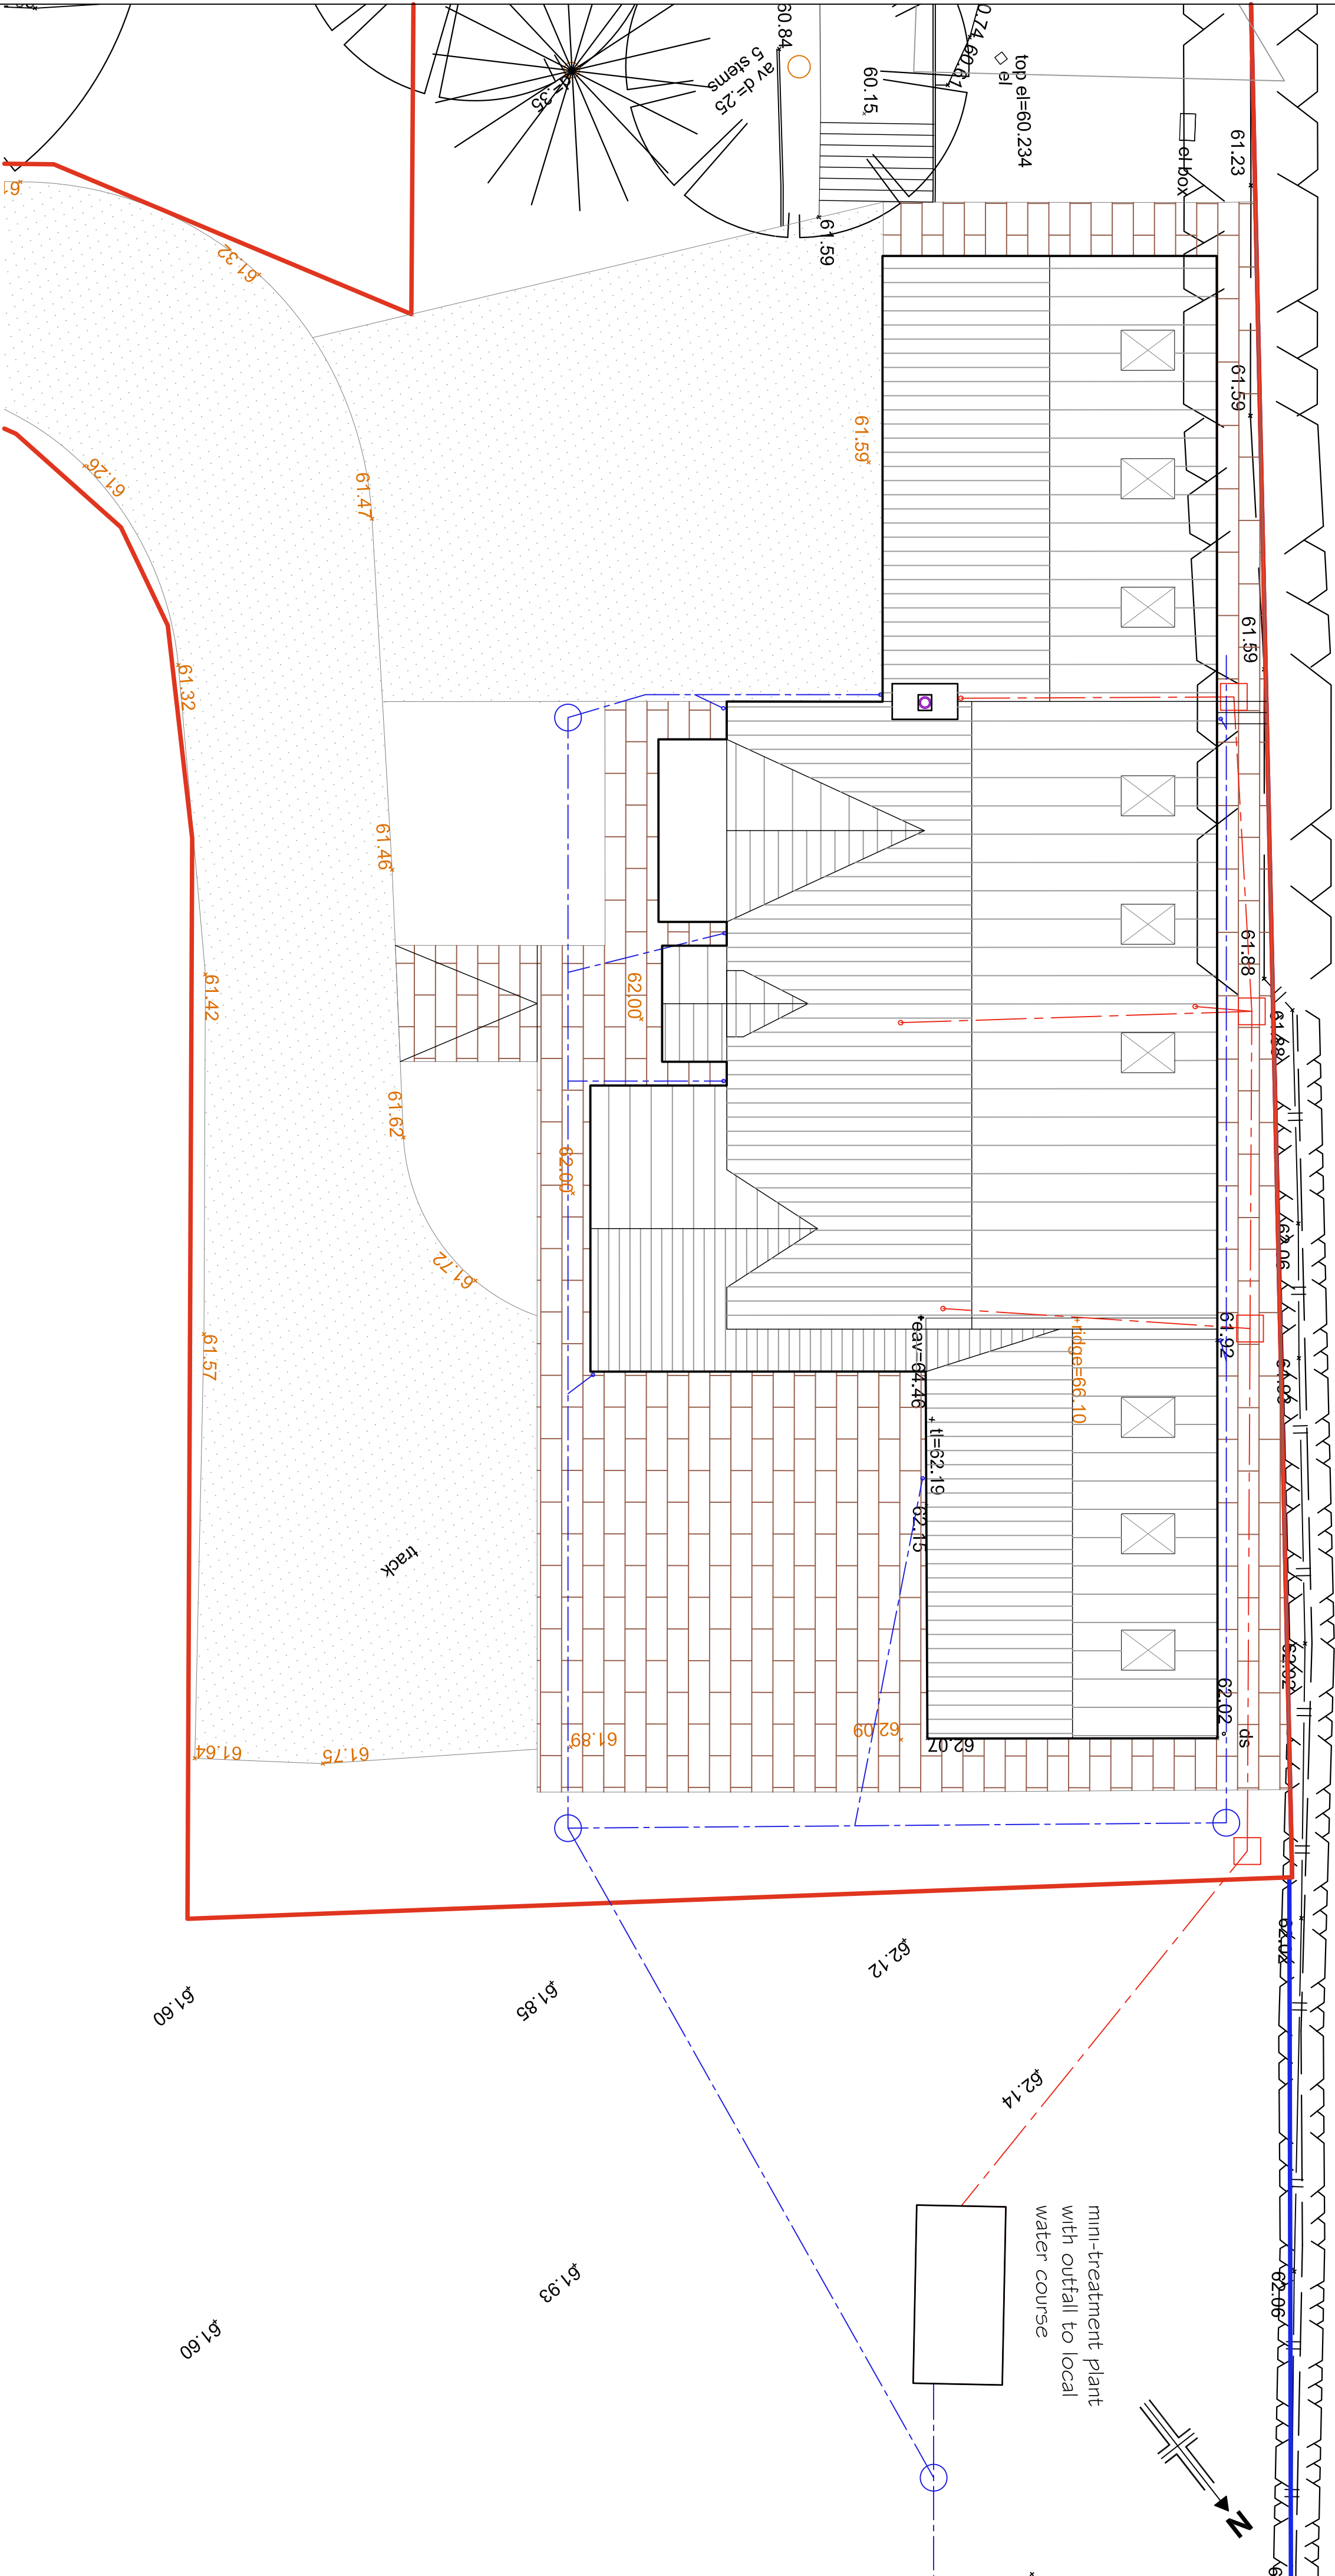

Proposed Private Surface Water

Proposed Private Foul Sewer



1:100 Scale

Mr & Mrs O Meara

Dale Hey Bungalow,
Preston Road, Ribchester

Indicative Drainage Layout as Proposed

Dwg No.

A4578-PL14

Rev.

P1

Date

September 2026

Drawn

DME

Checked

Approved

PSA Design Ltd
The Old Bank House, 6 Berry Lane,
Longridge, Preston, PR3 3JA
Tel. 01772 786066
www.psadesign.co.uk
mail@psadesign.co.uk

PSA
DESIGN

Reproduced from Superplan Data® by the permission of
Ordnance Survey® on behalf of the Controller of Her Majesty's
Stationery Office. © Crown Copyright 2002. All rights reserved.
Licence number AL100034996.