



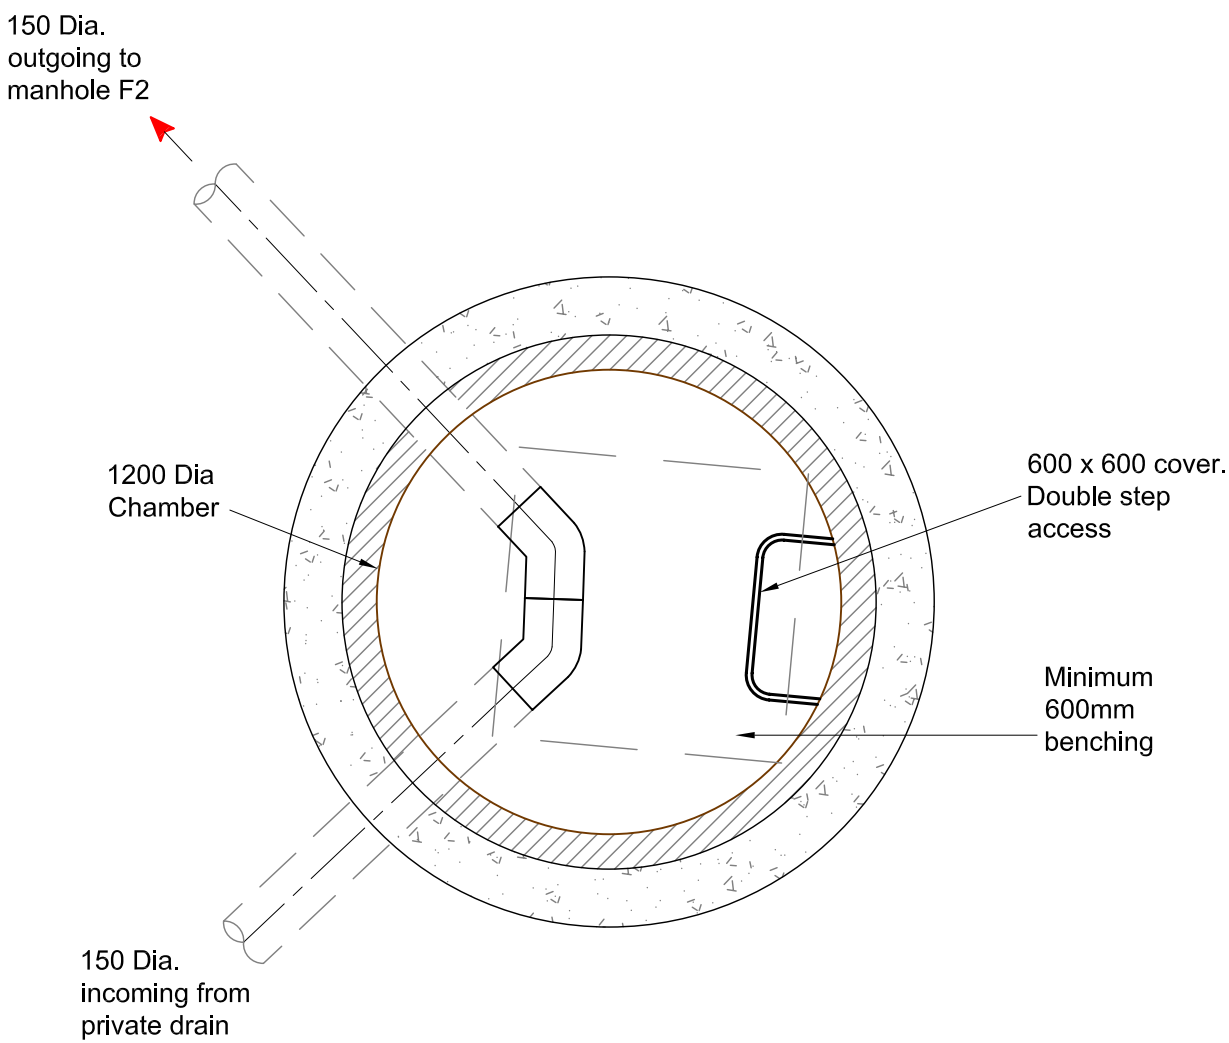


Manhole F1
Plan
Scale 1:20

CL 74.141
IL 71.550

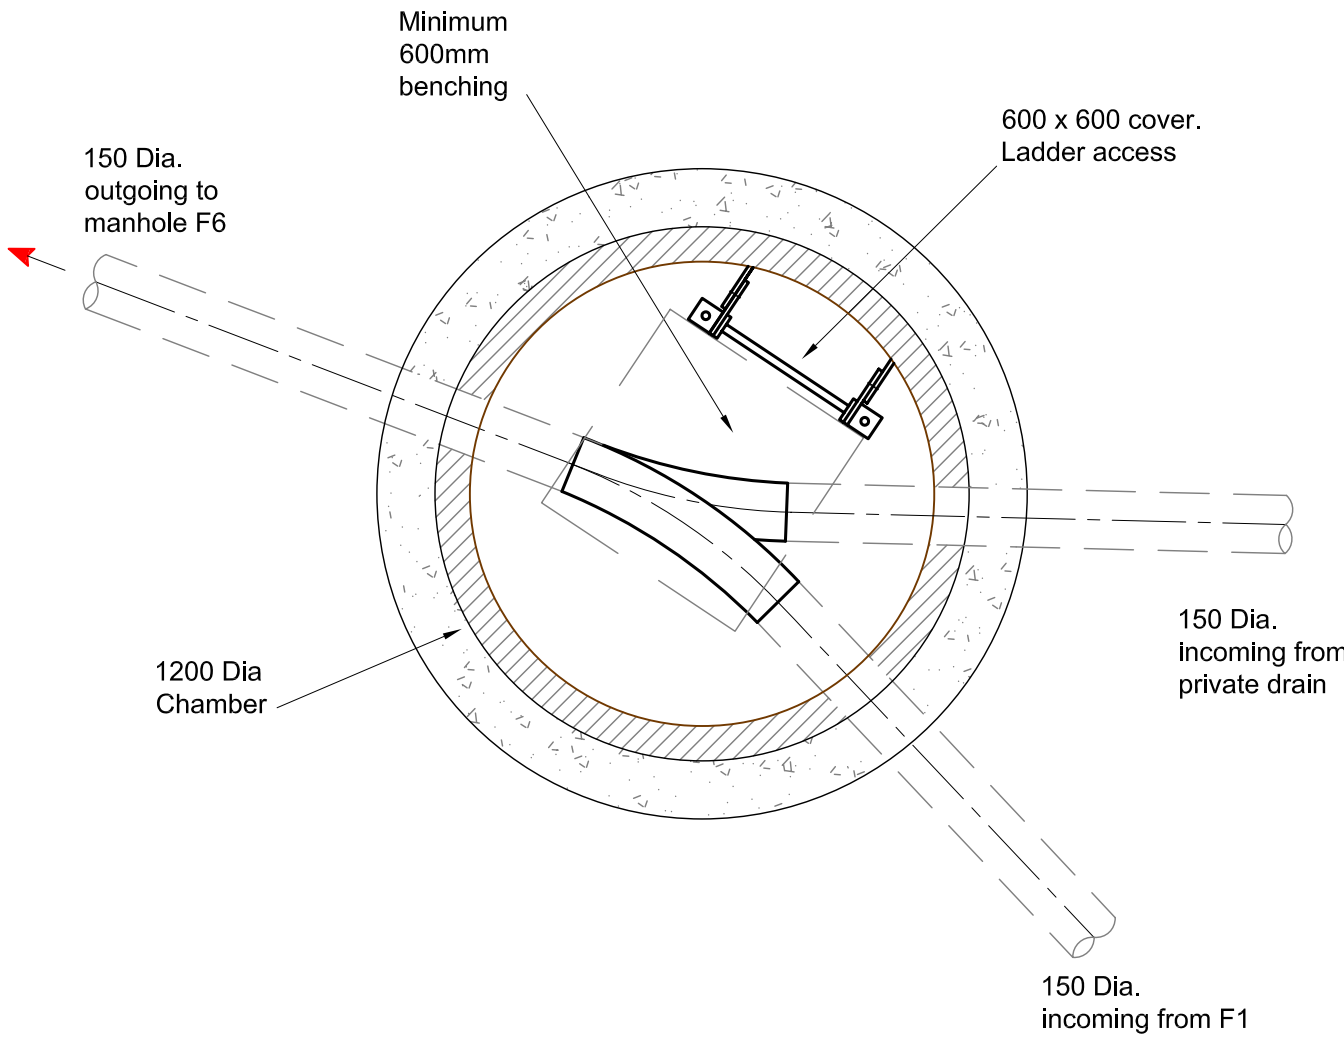


Manhole F2
Plan
Scale 1:20

CL 75.186
IL 71.396

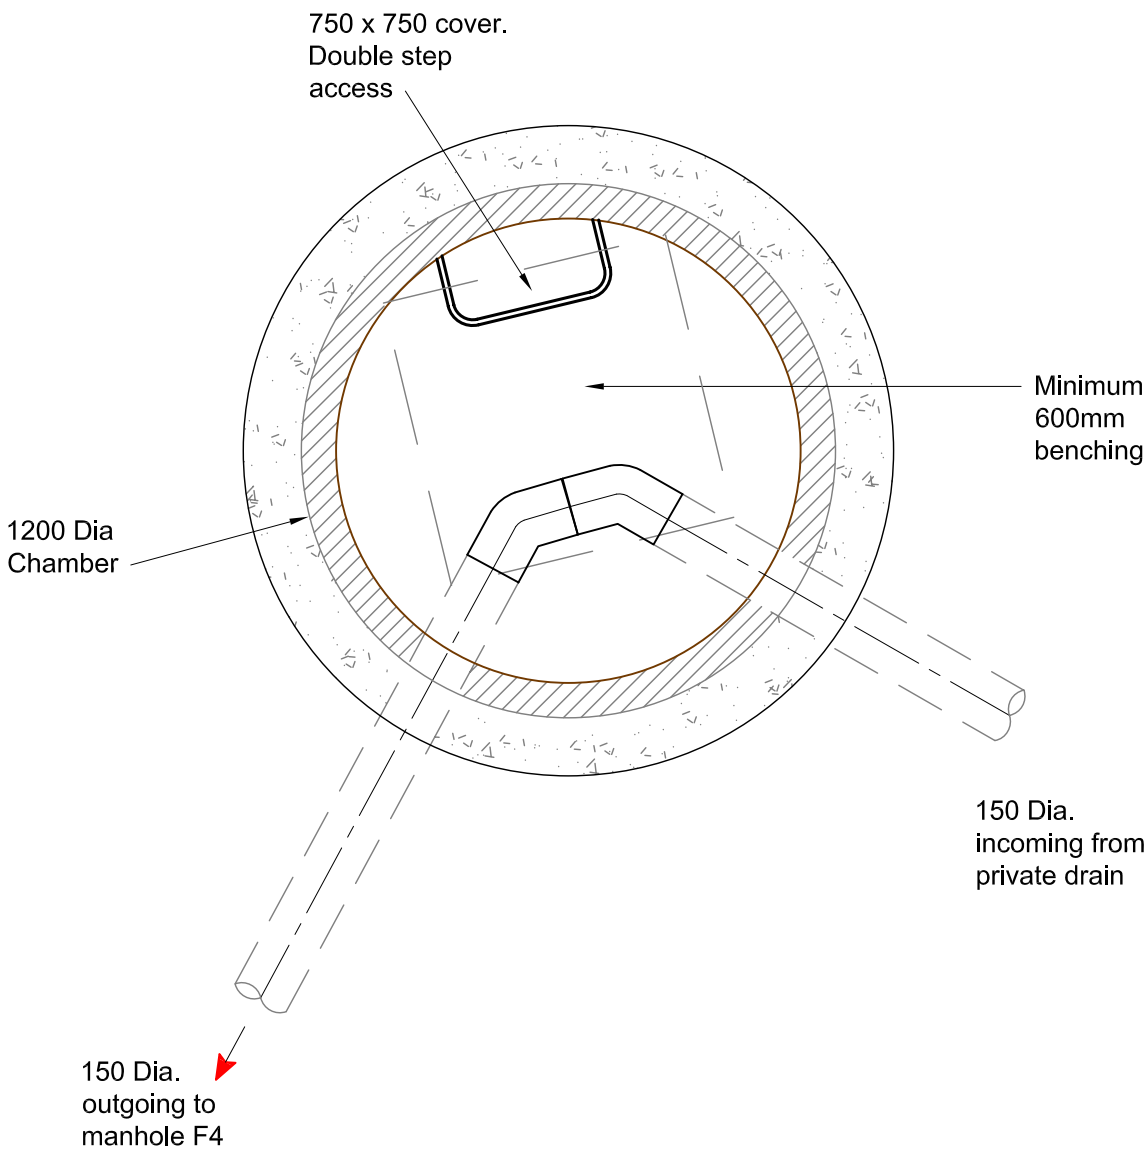


Manhole F3
Plan
Scale 1:20

CL 77.150
IL 75.500

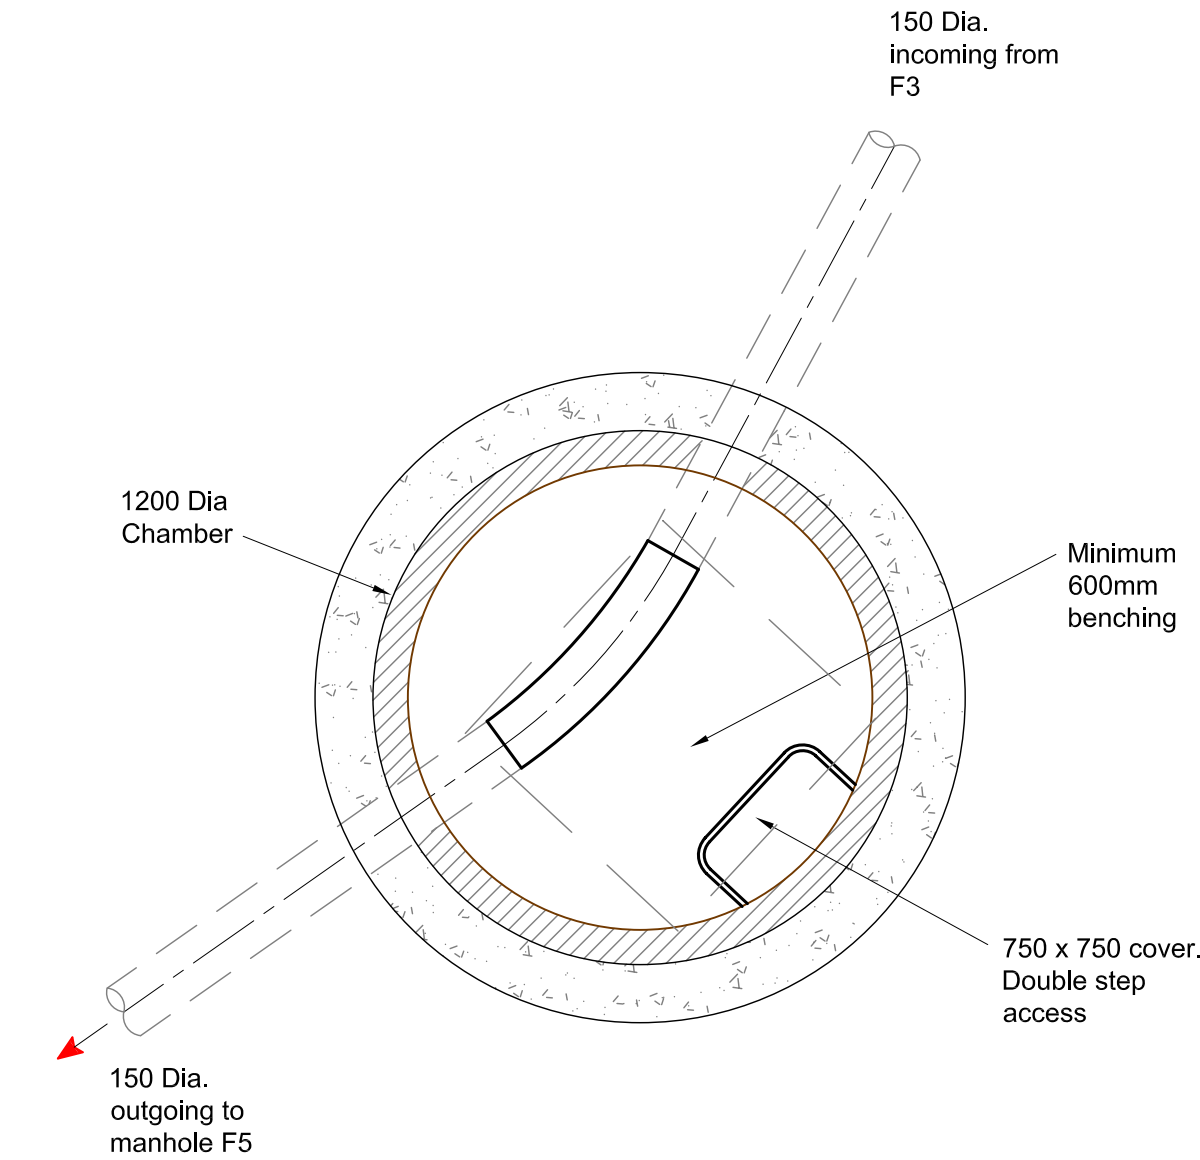


Manhole F4
Plan
Scale 1:20

CL 77.145
IL 75.347

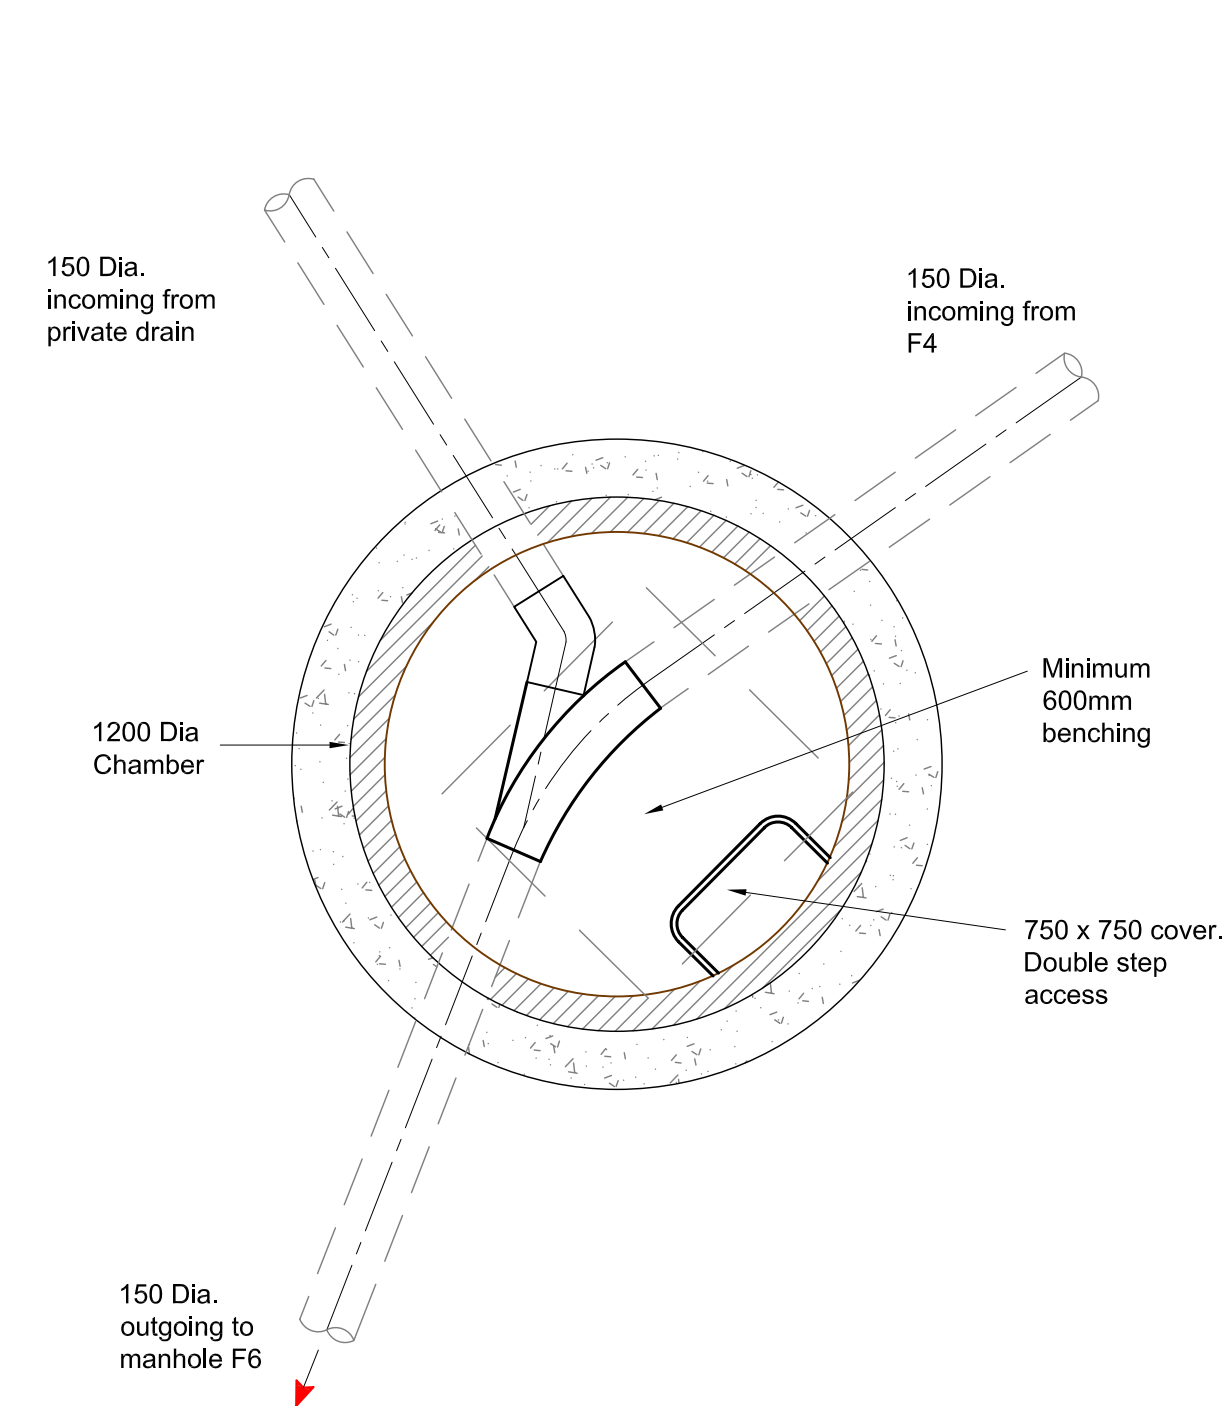


Manhole F5
Plan
Scale 1:20

CL 75.923
IL 74.273

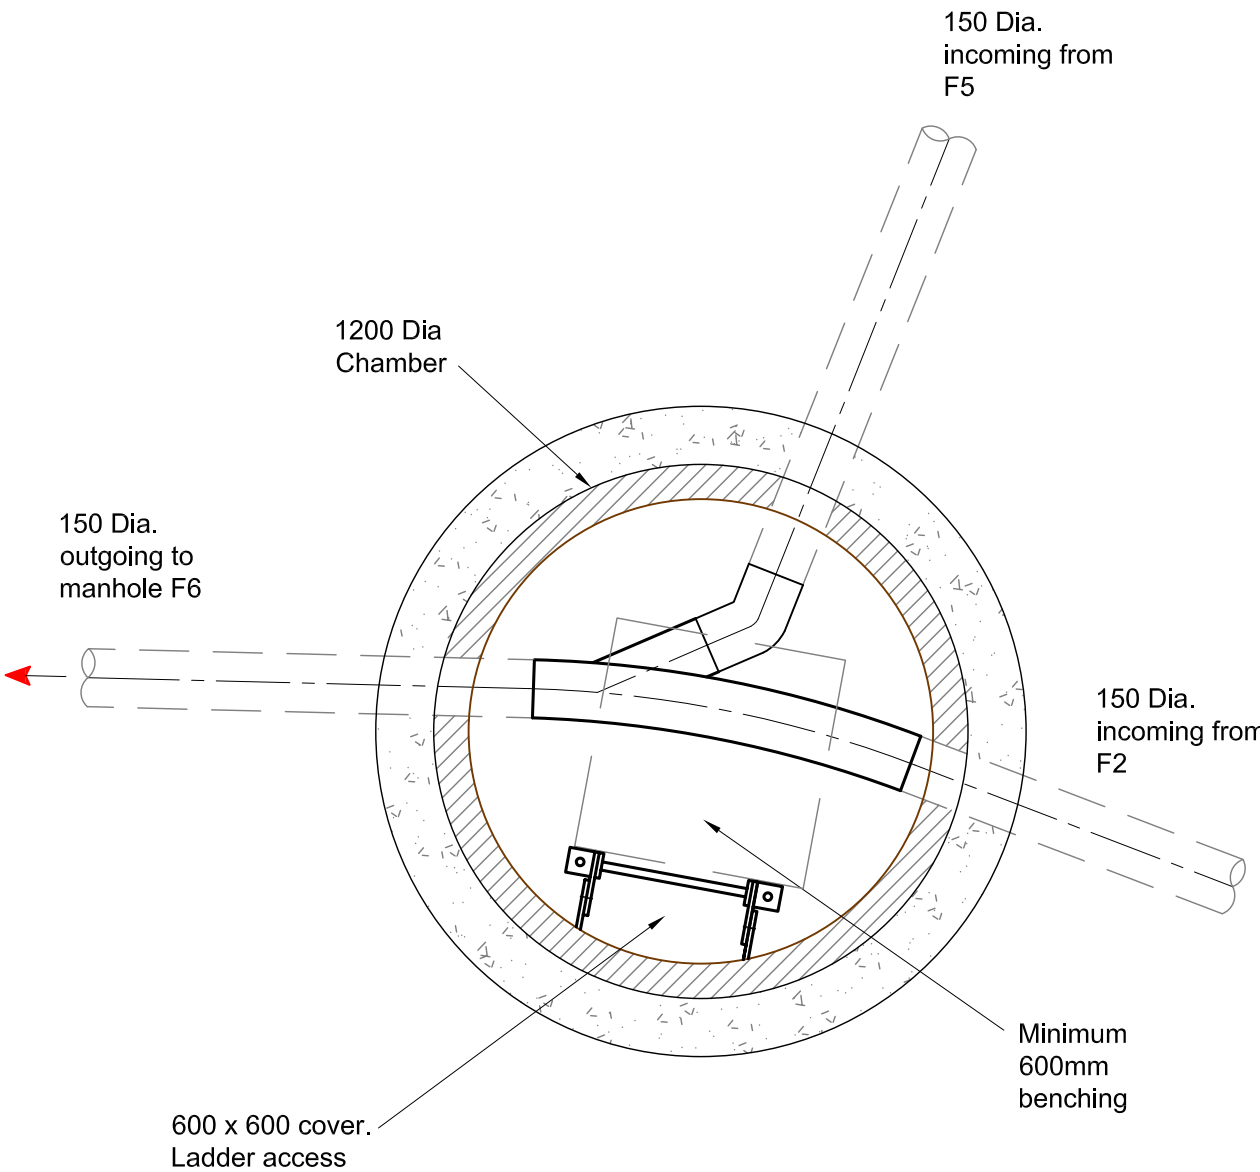


Manhole F6
Plan
Scale 1:20

CL 75.386
IL 71.306

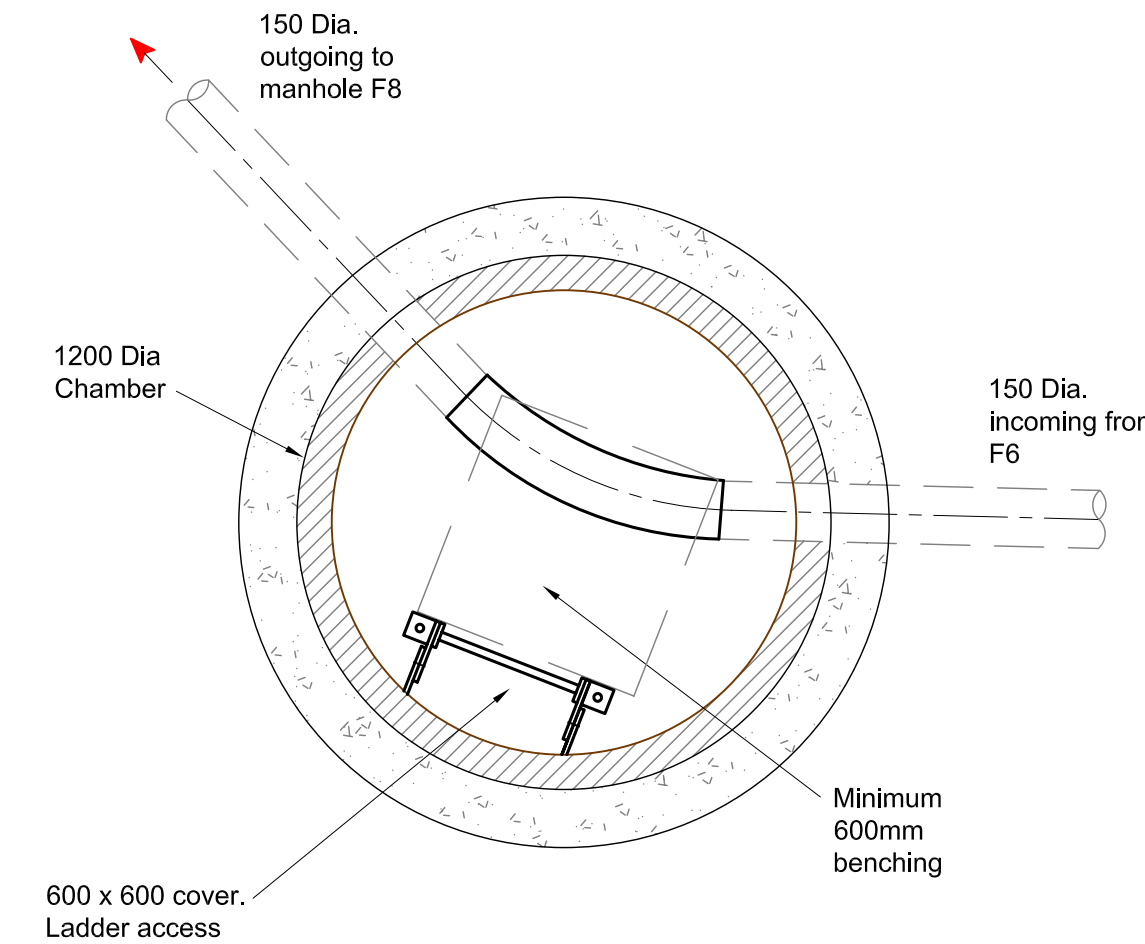

Manhole F7
Plan
Scale 1:20

CL 74.558
IL 71.114

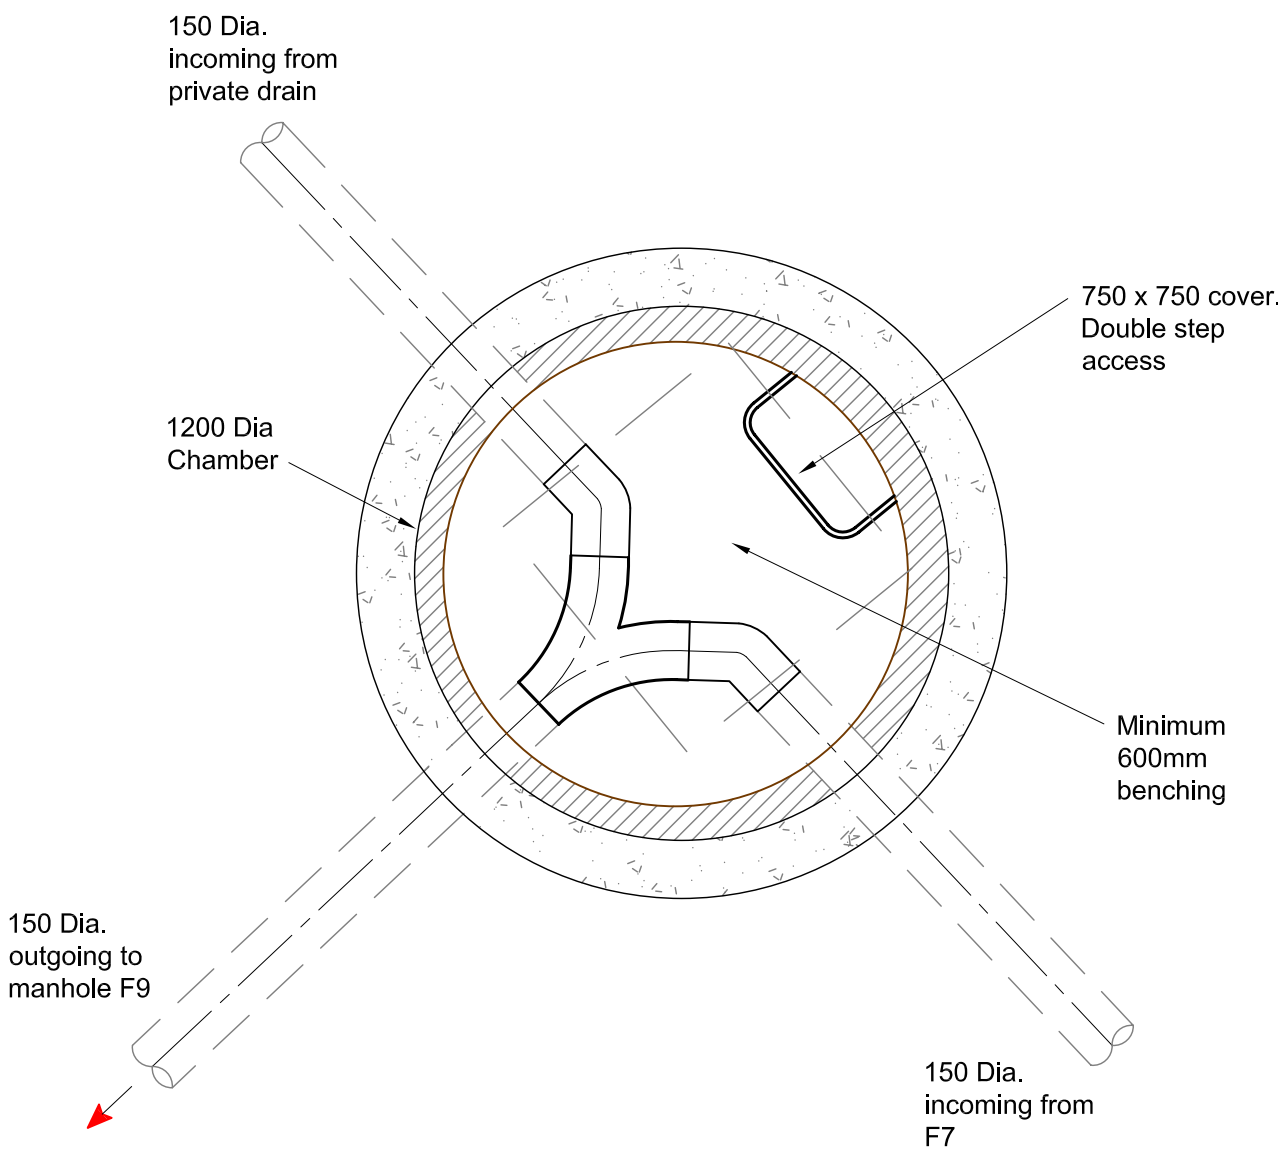

Manhole F8
Plan
Scale 1:20

CL 73.300
IL 70.913

Notes

- All works shall be in accordance with Sewers for Adoption 6th Edition and United Utilities Standard Details and Guidelines.
- Step Rungs shall be installed in accordance to BS EN 13101.
- Manholes shall be to United Utilities Standard Detail STND/01/001. Ladders, Safety chains and Handrailing shall be to Standard Detail STND/01/002. Back-drops shall be to Standard Detail STND/01/003.
- 150mm min concrete surround required for all adopted Manholes.
- Rocker pipes shall be provided in accordance with United Utilitie Standard Details.
- Pipe materials as table below or similar approved by United Utilities.

Pipe Materials Table

Pipe Materials Table	Pipe Materials Table
150	CLAYWARE
225	CLAYWARE
300	CLAYWARE
375	CONCRETE
450	CONCRETE
600	CONCRETE
750	CONCRETE
900	CONCRETE
1200	CONCRETE
1500	CONCRETE

Bedding and Surround Table

Depth to Soffit	Bedding and Surround Type
>1.2m	Class S
<1.2m	Class Z

Coopers Drawing List:

5399/01	Proposed Drainage Layout
5399/02	Proposed Drainage Longsections
5399/03	Proposed Highway Layout
5399/04	Proposed Highway Levels
5399/05	Highway Construction Details
5399/06	Drainage Construction Details
5399/07	Manhole Schedule
5399/08	Private Drainage Layout
5399/09	External Works Layout
5399/10	Section 38 Composite Plan
5399/11	Section 278 Works - Alderley
5399/12	Section 278 Works - Dlgmoor Road
5399/13	Foul Manhole Details
5399/14	Surface Water Manhole Details
5399/15	Flow Control Manhole Details
5399/16	Section 278 Works - Highway Construction Details

APPROVAL

coopers
chartered consulting engineers

Tel: 01244 684910
Fax: 01244 684911
Email: admin@cooperassociates.co.uk
Web: http://coopers.co.uk

Park House
Sandpiper Court
Chester Business Park
Chester
CH4 9QU

Client **millermhomes**
Miller Homes Limited - North West Region

Project **Primrose Mill, Woone Lane
Clitheroe**

Title **Foul Water Manhole Details**
Sheet 1 of 2

DRAWING NUMBER	SCALE at A1	DATE	July 2012	REVISION
5454/13-1		DRAWN	AH	A
		CHECKED	AJ	